
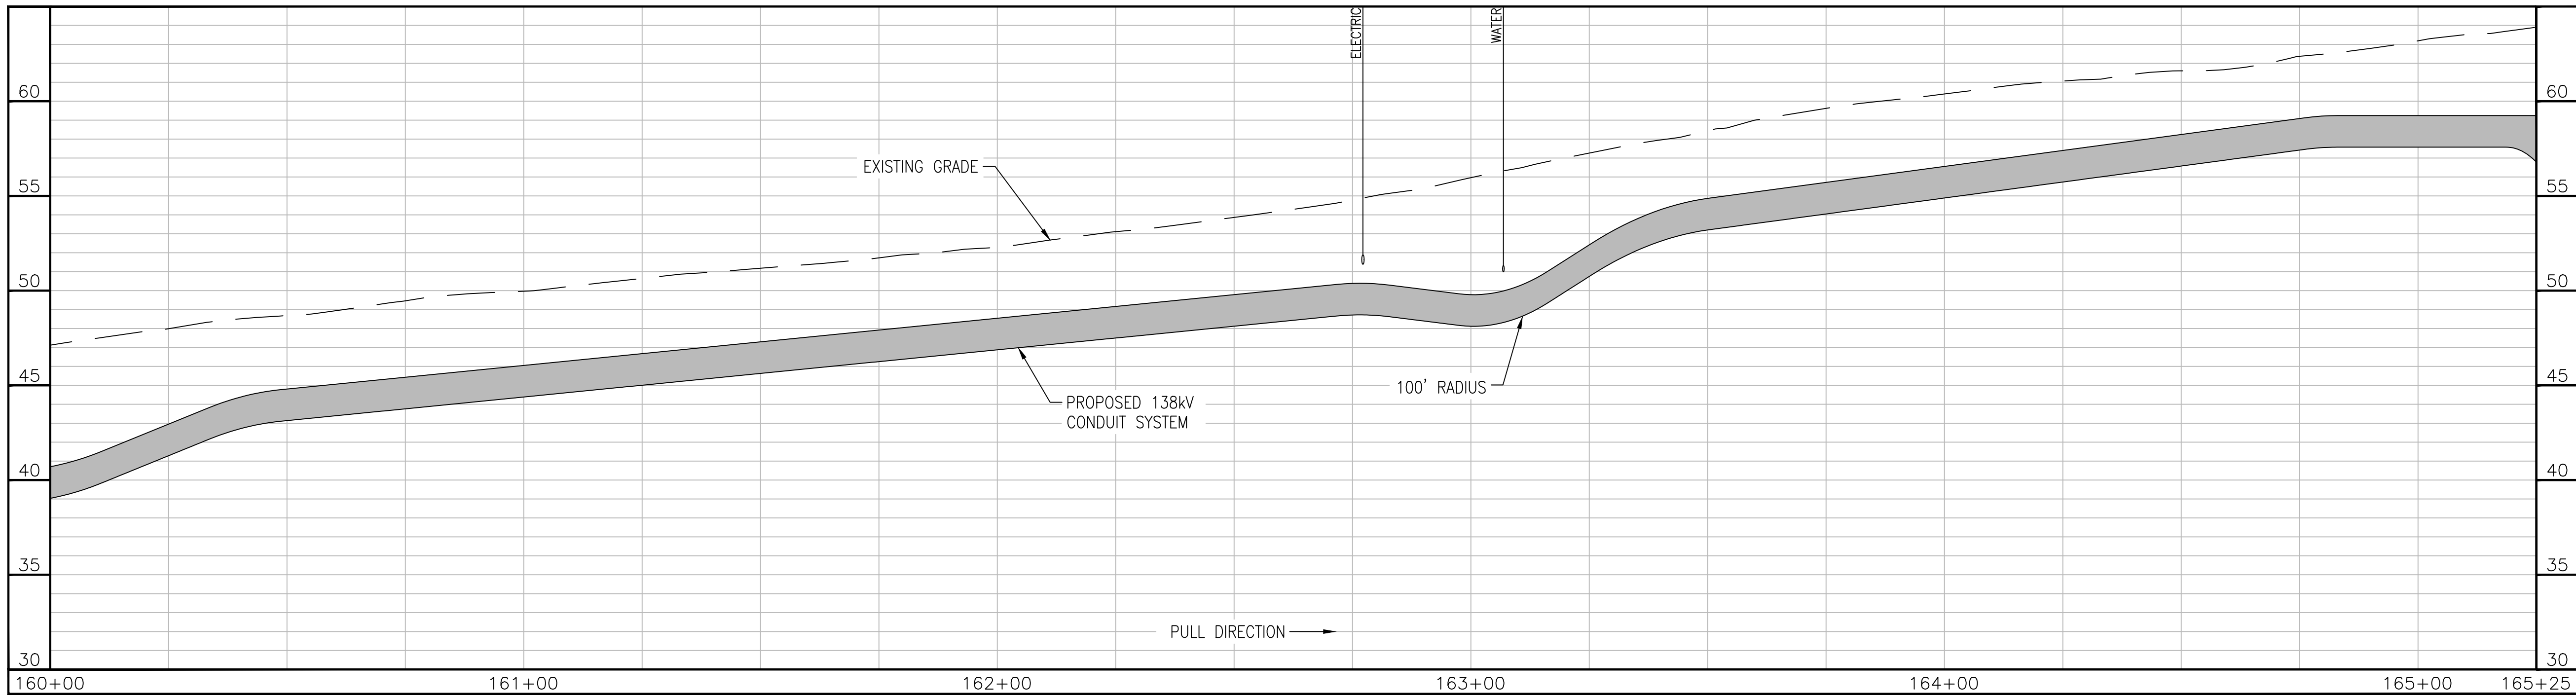


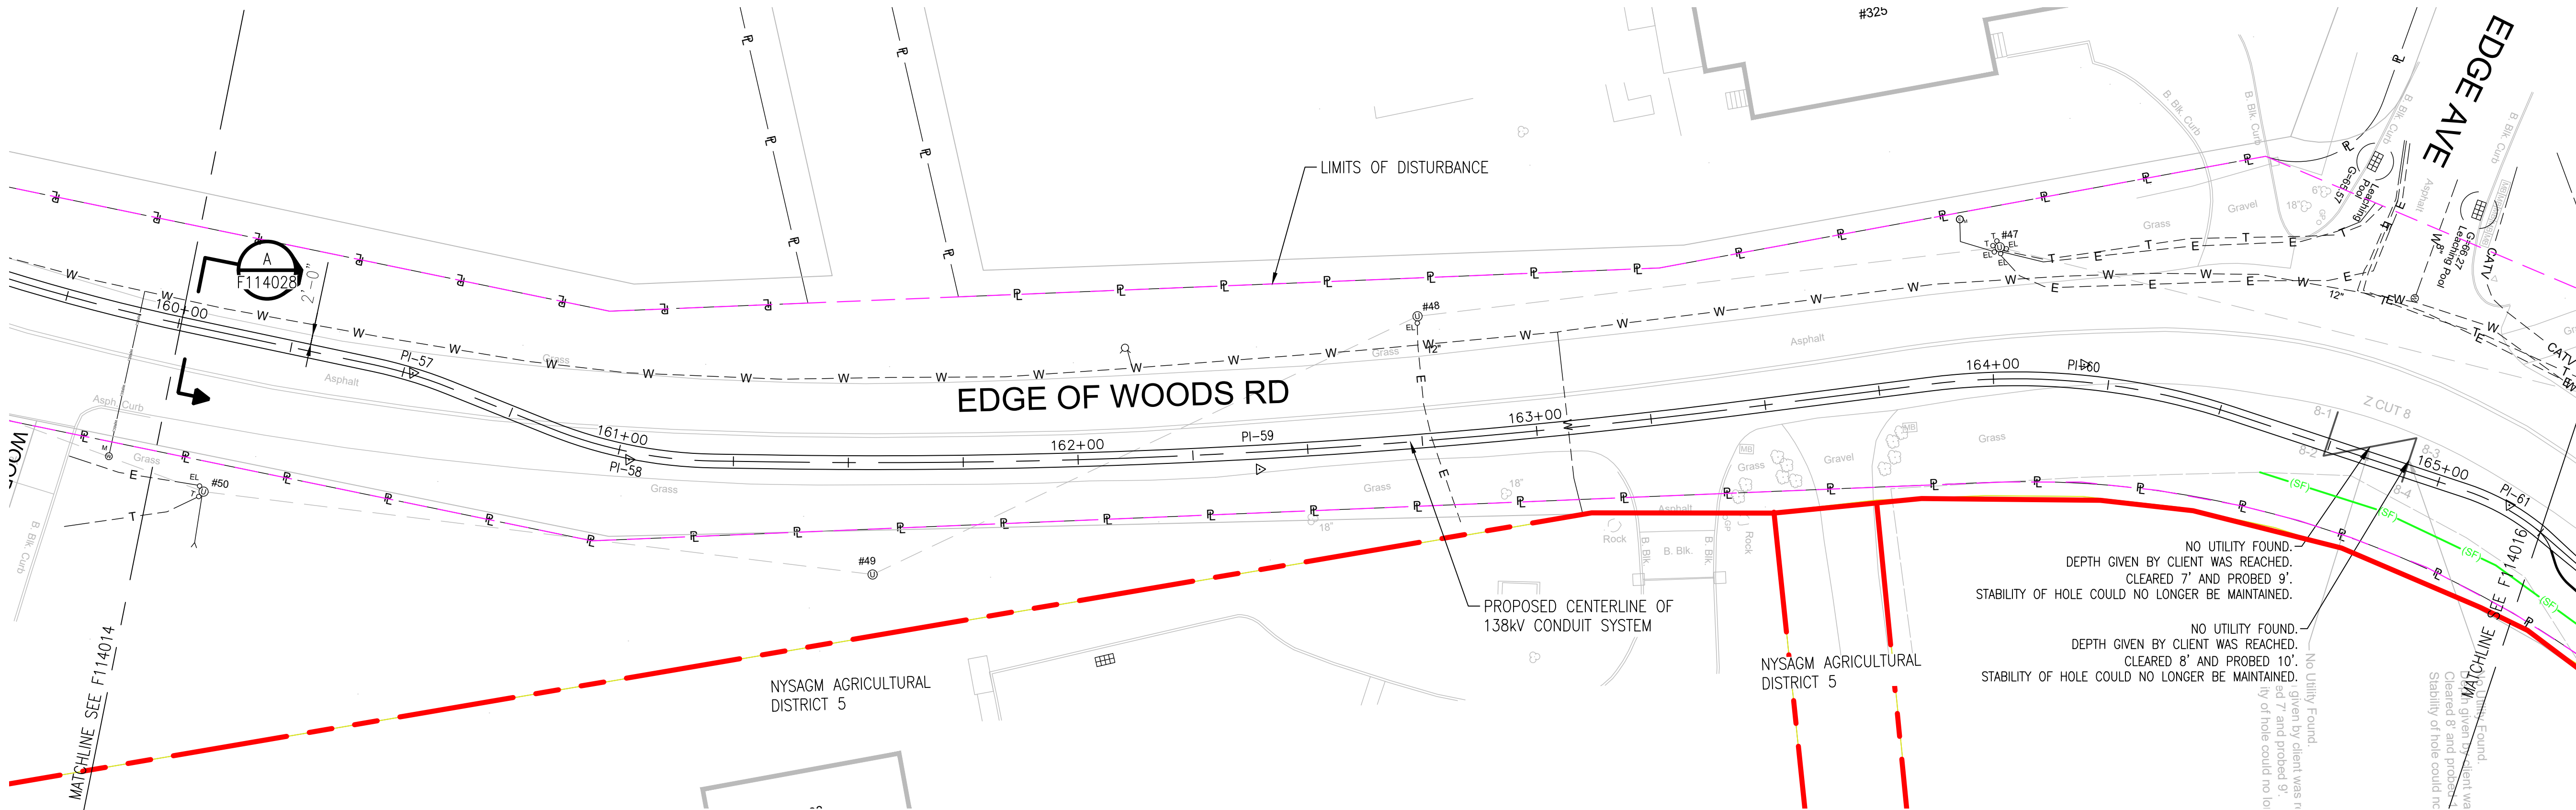


APPROVED WITH
CORRECTIONS AS NOTED
PSEG Long Island

THIS APPROVAL SHALL NOT RELIEVE
THE CONTRACTOR FROM ENTIRE
RESPONSIBILITY FOR DIMENSIONAL
ACCURACY, CONFORMANCE WITH
REFERENCED SPECIFICATIONS, CODES
AND ALL LIABILITY UNDER CONTRACT.

PER: _____
DATE: _____

NOTE:
1. SEE F113982 AND F113983 FOR ROUTE DATA TABLE AND PULLING CALCULATIONS.

IT IS A VIOLATION OF THE PROFESSIONAL LICENSE LAW
FOR ANY PERSON TO ALTER THIS DRAWING IN ANY WAY,
UNLESS ACTING UNDER THE DIRECTION OF A LICENSED
PROFESSIONAL ENGINEER. THE ALTERING CONSULTANT
SHALL AFFIX THEIR SEAL AND THE NOTATION "ALTERED BY"
FOLLOWED BY THEIR SIGNATURE AND DATE OF ALTERATION.

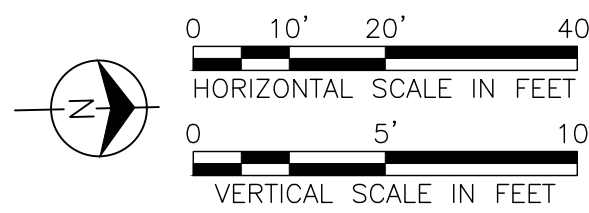

ISSUED
FOR PERMITTING

NO.	DATE	W.O.	DESCRIPTION	DWN BY	CHK BY	REVISED	APPRO
0	10/03/2025	ISSUED FOR PERMITTING	JAS	LAF	DAG		
0	07/25/2025	ISSUED FOR CONSTRUCTION	JAS	LAF	DAG		
REV	DATE	DESCRIPTION	DRAWN	REVIEW	APPR		

**BURNS
MEDONNELL**

PROJ. NO. 154527

NO.	DATE	W.O.	DESCRIPTION	DWN BY	CHK BY	REVISED	APPRO
0	10/03/2025	ISSUED FOR PERMITTING	JAS	LAF	DAG		
0	07/25/2025	ISSUED FOR CONSTRUCTION	JAS	LAF	DAG		
REV	DATE	DESCRIPTION	DRAWN	REVIEW	APPR		

Long Island Power Authority
TIANA - BUELL
OPS BLDG 1
69kV TRANSMISSION LINE

PLAN AND PROFILE SHEET 31 OF 47
SOUTHAMPTON TO DEERFIELD 138kV OPERATED AT 69kV
UNDERGROUND TRANSMISSION ENGINEERING

PSEG LONG ISLAND
175 East Old Country Road
Hicksville, New York

SCALE
HORIZ: 1"=20' VERT: 1"=5'


DRAWING NO. F114015
VENDOR DWG. NO. RVF69-FU-01188
CABINET NO. FOLDER NO. 0



NOTE:

1. SEE F113982 AND F113983 FOR ROUTE DATA TABLE AND PULLING CALCULATIONS.

IT IS A VIOLATION OF THE PROFESSIONAL LICENSE LAW FOR ANY PERSON TO ALTER THIS DRAWING IN ANY WAY, UNLESS ACTING UNDER THE DIRECTION OF A LICENSED PROFESSIONAL ENGINEER. THE ALTERING CONSULTANT SHALL AFFIX THEIR SEAL AND THE NOTATION "ALTERED BY" FOLLOWED BY THEIR SIGNATURE AND DATE OF ALTERATION.

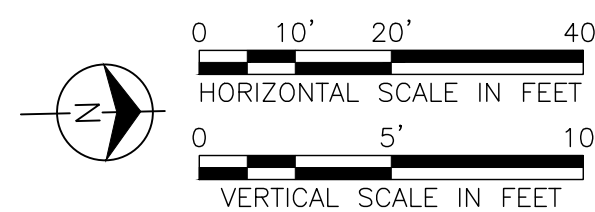

ISSUED
FOR PERMITTING

[illegible]

**BURNS
MCDONNELL**

PROJ. NO. 154527


ISSUE									
	10/03/2024	L39101	ORIGINAL ISSUE						
NO.	DATE	W.O.	DESCRIPTION	DWIN BY	CKD BY	REVIEWED	APPO		

 PSEG LONG ISLAND 175 East Old Country Road Hicksville, New York			
SCALE HORIZ: 1"=20' VERT: 1"=5'		VENDOR DWG. NO.	
DRAWING NO. F114015i	SMART NO. RVF69-FU-01188		REVISION 0
SYSTEM GRID NUMBER		CABINET NO.	FOLDER NO.

A

B


C

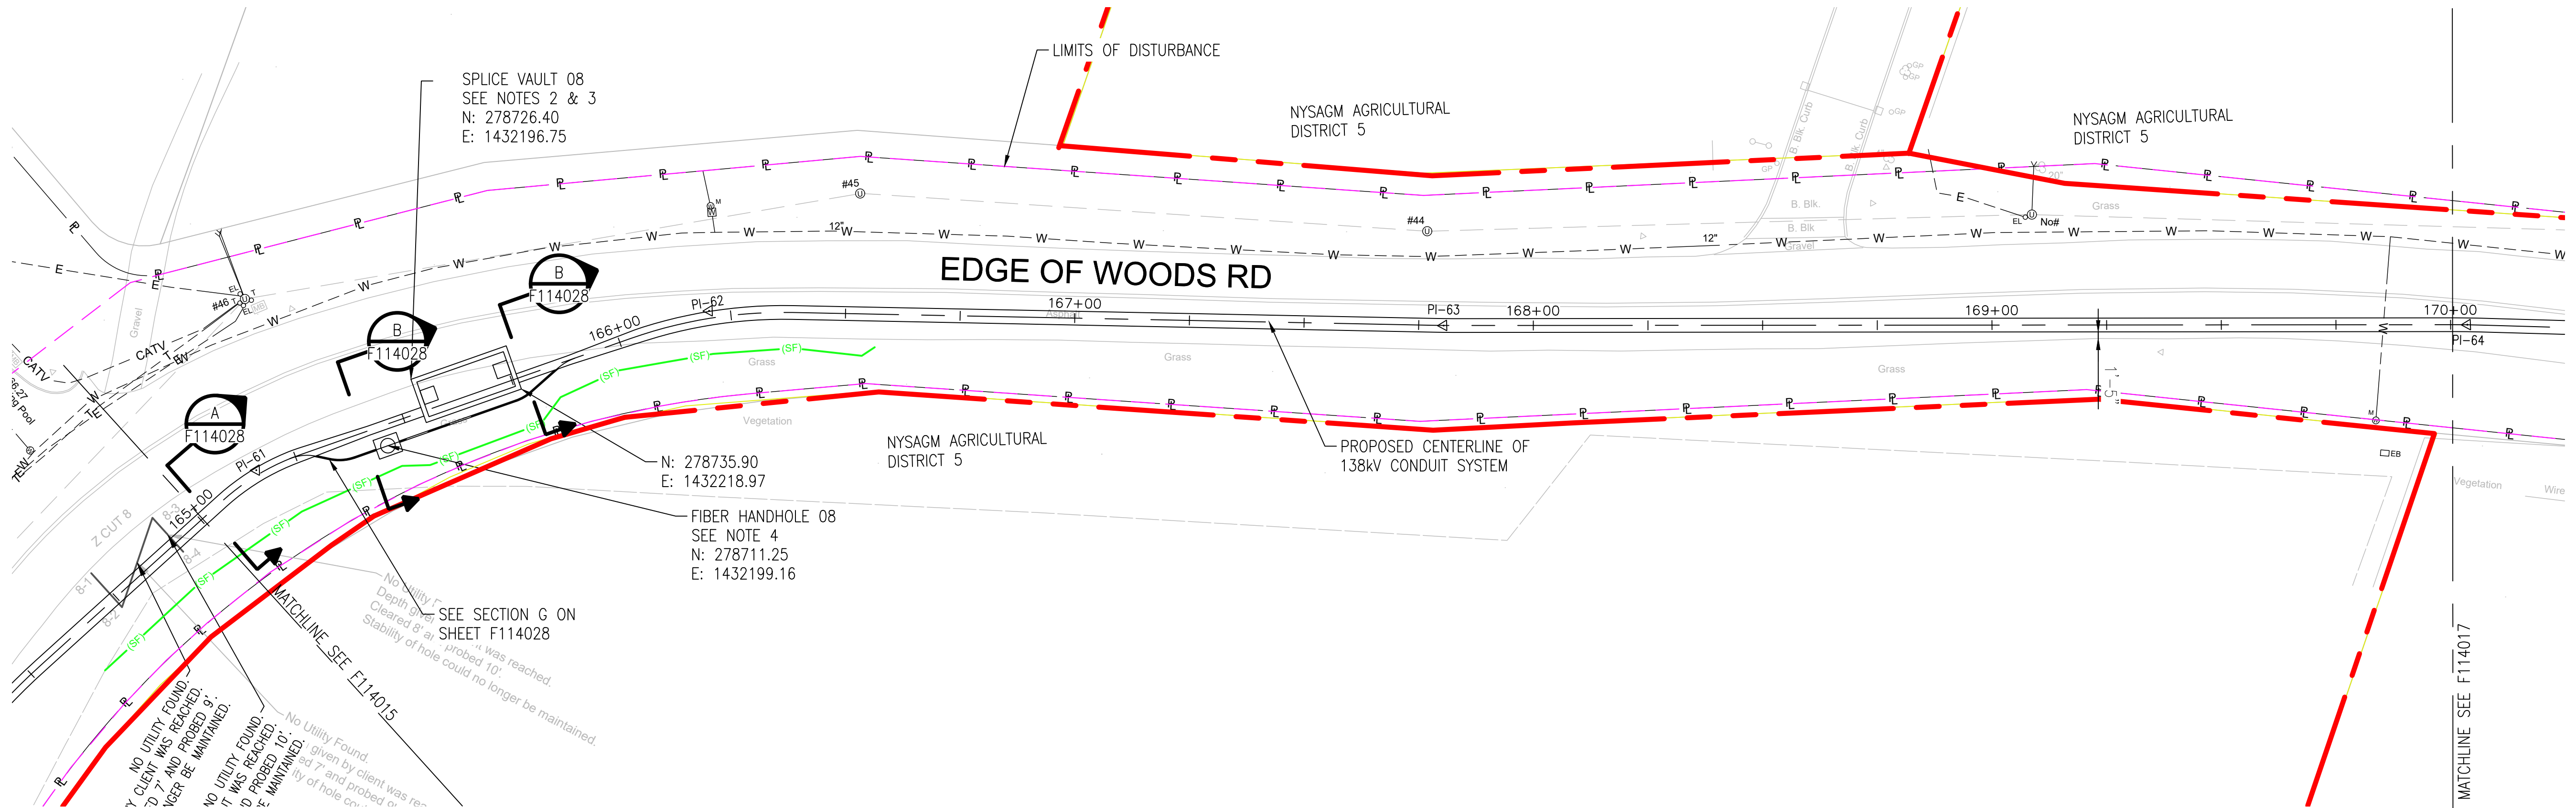

D

E



F

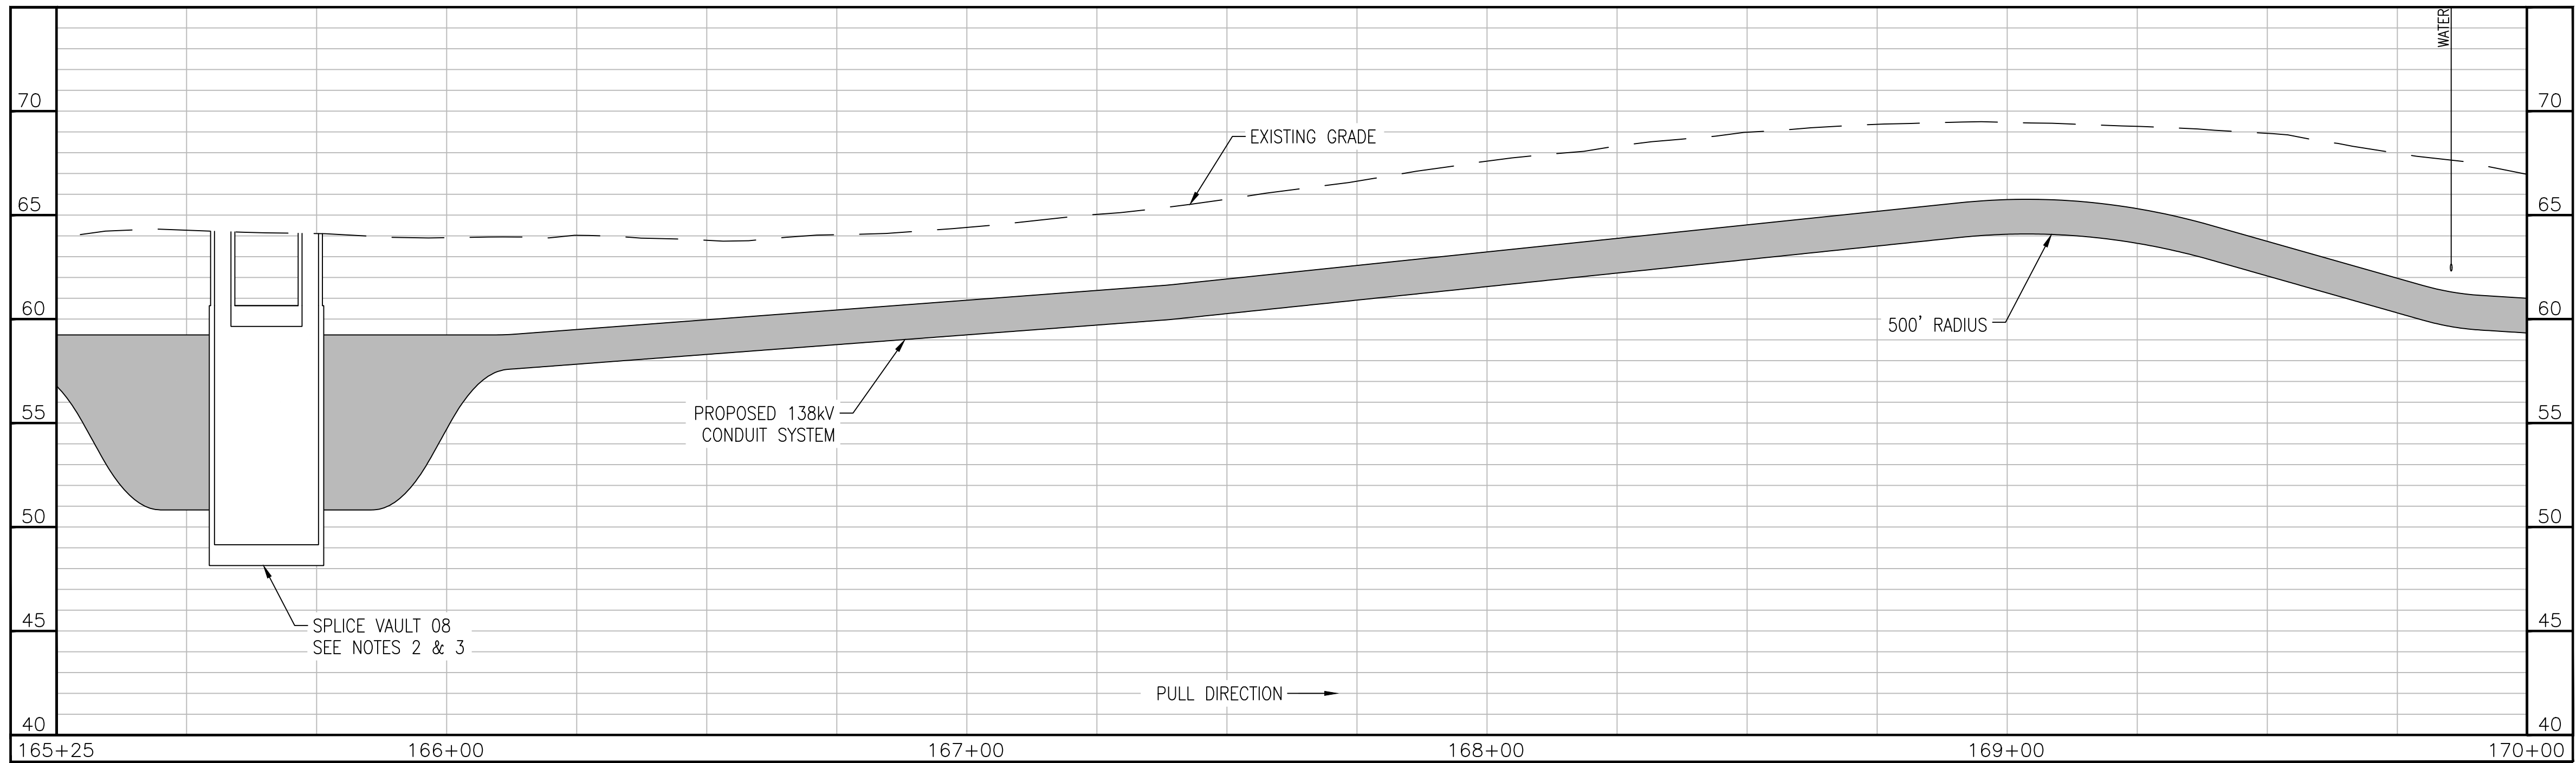

NOTES:

- SEE F113982 AND F113983 FOR ROUTE DATA TABLE AND PULLING CALCULATIONS.
- SEE F114522, F114550 AND F114556 THROUGH F114558 FOR SPLICE VAULT DETAILS.
- SPLICE VAULT DESIGN TO BE CONFIRMED BY PSEG LONG ISLAND IN SUBSEQUENT STAGES OF DESIGN.
- SEE F114031 FOR FIBER HANDHOLE DETAILS.

IT IS A VIOLATION OF THE PROFESSIONAL LICENSE LAW FOR ANY PERSON TO ALTER THIS DRAWING IN ANY WAY, UNLESS ACTING UNDER THE DIRECTION OF A LICENSED PROFESSIONAL ENGINEER. THE ALTERING CONSULTANT SHALL AFFIX THEIR SEAL AND THE NOTATION "ALTERED BY" FOLLOWED BY THEIR SIGNATURE AND DATE OF ALTERATION.

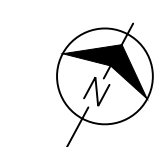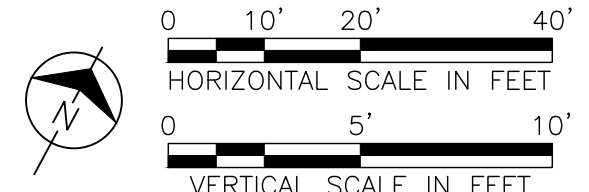

ISSUED
FOR PERMITTING

REV	DATE	DESCRIPTION	DRAWN	REVIEW	APPR
0	10/03/2025	ISSUED FOR PERMITTING	JAS	LAF	DAG
0	07/25/2025	ISSUED FOR CONSTRUCTION	JAS	LAF	DAG



PROJ. NO. 154527

NO.	DATE	W.O.	DESCRIPTION	DESIGNED	CHKD BY	REVIEWED	APPROVED
1	10/03/2025	L8101	ORIGINAL ISSUE	JAS	KL	H. MOELLER	H. MOELLER

Long Island Power Authority
TIANA - BUELL
OPS BLDG 1
69kV TRANSMISSION LINE

PLAN AND PROFILE SHEET 32 OF 47
SOUTHAMPTON TO DEERFIELD 138kV OPERATED AT 69kV
UNDERGROUND TRANSMISSION ENGINEERING

PSEG LONG ISLAND
175 East Old Country Road
Hicksville, New York

SCALE
HORIZ: 1"=20' VERT: 1"=5'


DRAWING NO. F114016
SMART NO. RVF69-FU-01189
CABINET NO. FOLDER NO. 0

APPROVED WITH
CORRECTIONS AS NOTED
PSEG Long Island

THIS APPROVAL SHALL NOT RELIEVE
THE CONTRACTOR FROM ENTIRE
RESPONSIBILITY FOR DIMENSIONAL
ACCURACY, CONFORMANCE WITH
REFERENCED SPECIFICATIONS, CODES
AND ALL LIABILITY UNDER CONTRACT.

PER: _____
DATE: _____


TEMP
DWG.
NO. ---

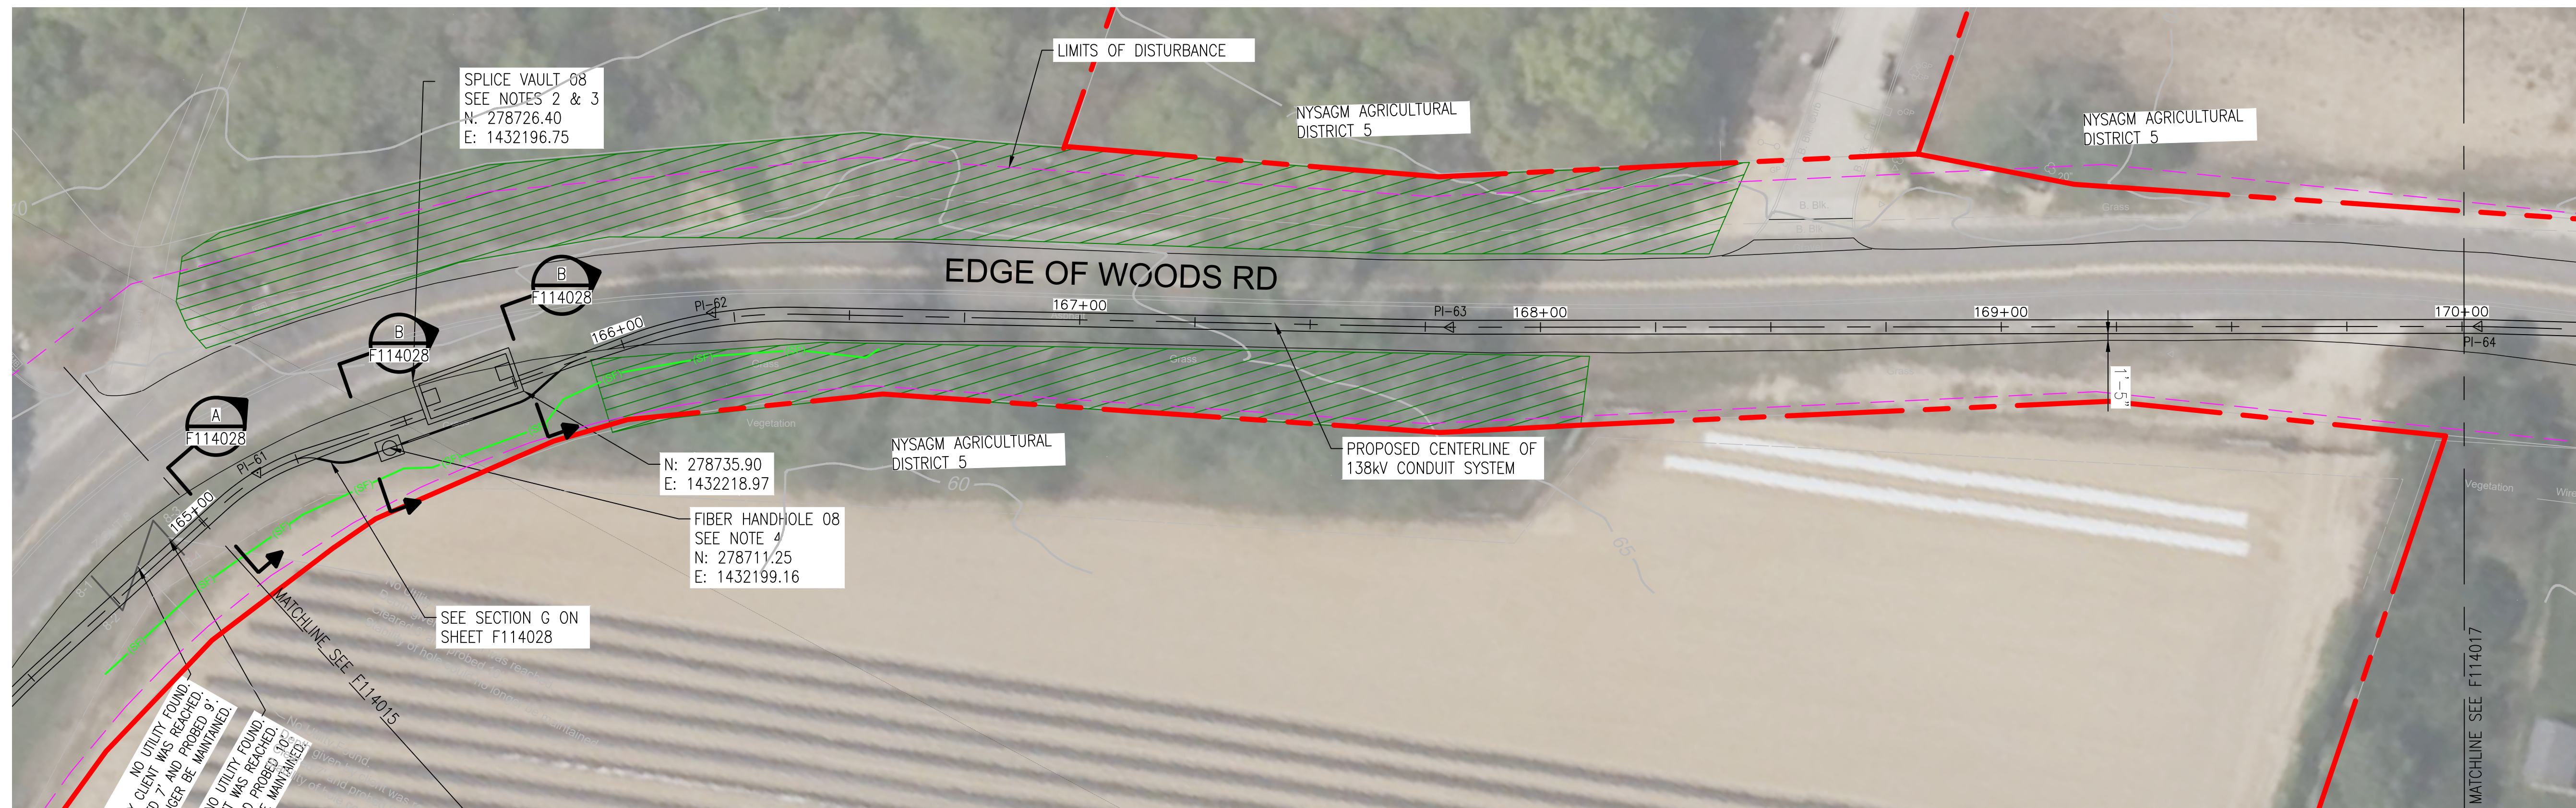

NOTES:

1. SEE F113982 AND F113983 FOR ROUTE DATA TABLE AND PULLING CALCULATIONS.
2. SEE F114522, F114550 AND F114556 THROUGH F114558 FOR SPLICE VAULT DETAILS.
3. SPLICE VAULT DESIGN TO BE CONFIRMED BY PSEG LONG ISLAND IN SUBSEQUENT STAGES OF DESIGN.
4. SEE F114031 FOR FIBER HANDHOLE DETAILS.

IT IS A VIOLATION OF THE PROFESSIONAL LICENSE LAW FOR ANY PERSON TO ALTER THIS DRAWING IN ANY WAY, UNLESS ACTING UNDER THE DIRECTION OF A LICENSED PROFESSIONAL ENGINEER. THE ALTERING CONSULTANT SHALL AFFIX THEIR SEAL AND THE NOTATION "ALTERED BY" FOLLOWED BY THEIR SIGNATURE AND DATE OF ALTERATION.

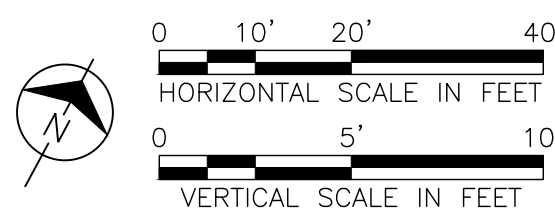

ISSUED
FOR PERMITTING

[illegible]

**BURNS
MCDONNELL**

PRJ. NO. 154527



ISSUE								
	10/03/2024	L.89101	ORIGINAL ISSUE		JS	EX	N MODEL FE	N MODEL FE
NO.	DATE	W.O.	DESCRIPTION		DWN BY	CXD BY	REVIEWED	APPD

Long Island Power Authority TIANA - BUELL OPS BLDG 1 69KV TRANSMISSION LINE			
PLAN AND PROFILE SHEET 32 OF 47 SOUTHAMPTON TO DEERFIELD 138KV OPERATED AT 69KV UNDERGROUND TRANSMISSION ENGINEERING			
 PSEG LONG ISLAND 175 East 91st Street Hicksville, New York			
SCALE HORIZ: 1"=20' VERT: 1"=5'		VENDOR DWG. NO.	
DRAWING NO. F114016i	SMART NO. RVF69-FU-01189	REVISION 0	
SYSTEM GRD NUMBER		CABINET NO.	FOLDER NO.

APPROVED WITH
CORRECTIONS AS NOTED
PSEG Long Island

THIS APPROVAL SHALL NOT RELIEVE
THE CONTRACTOR FROM ENTIRE
RESPONSIBILITY FOR DIMENSIONAL
ACCURACY, CONFORMANCE WITH
REFERENCED SPECIFICATIONS, CODES
AND ALL LIABILITY UNDER CONTRACT.

PER: _____
DATE: _____

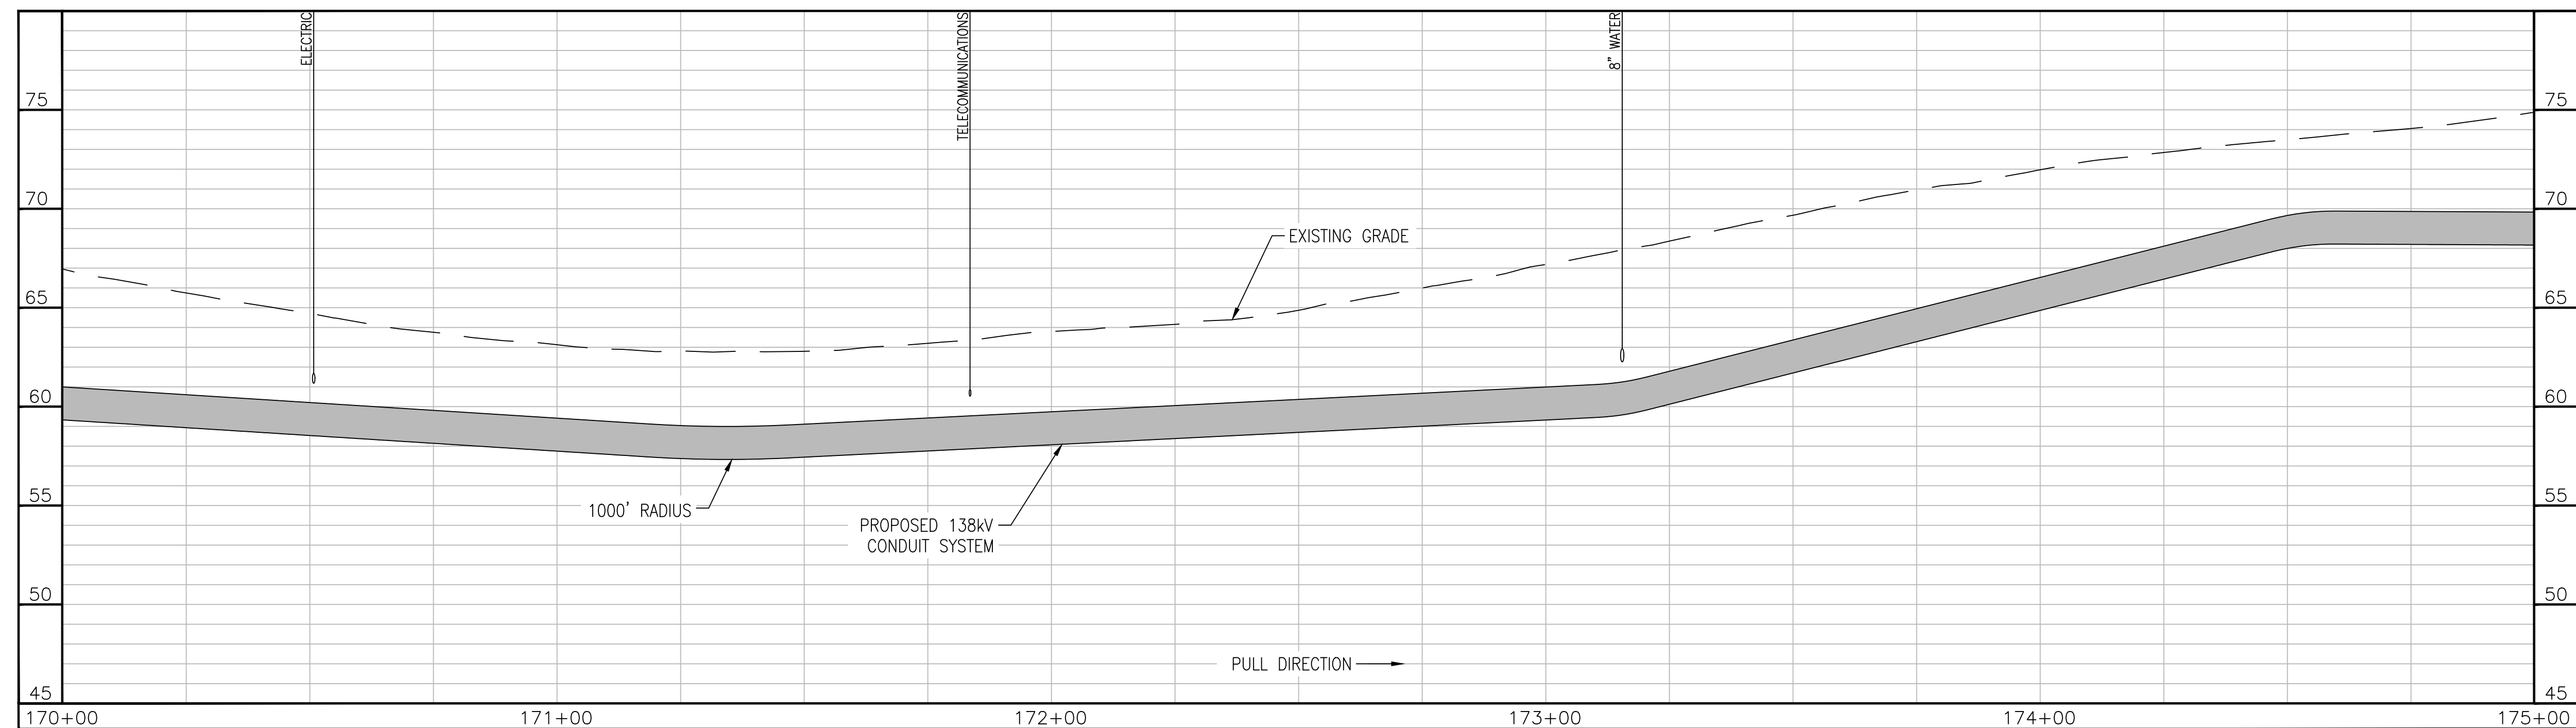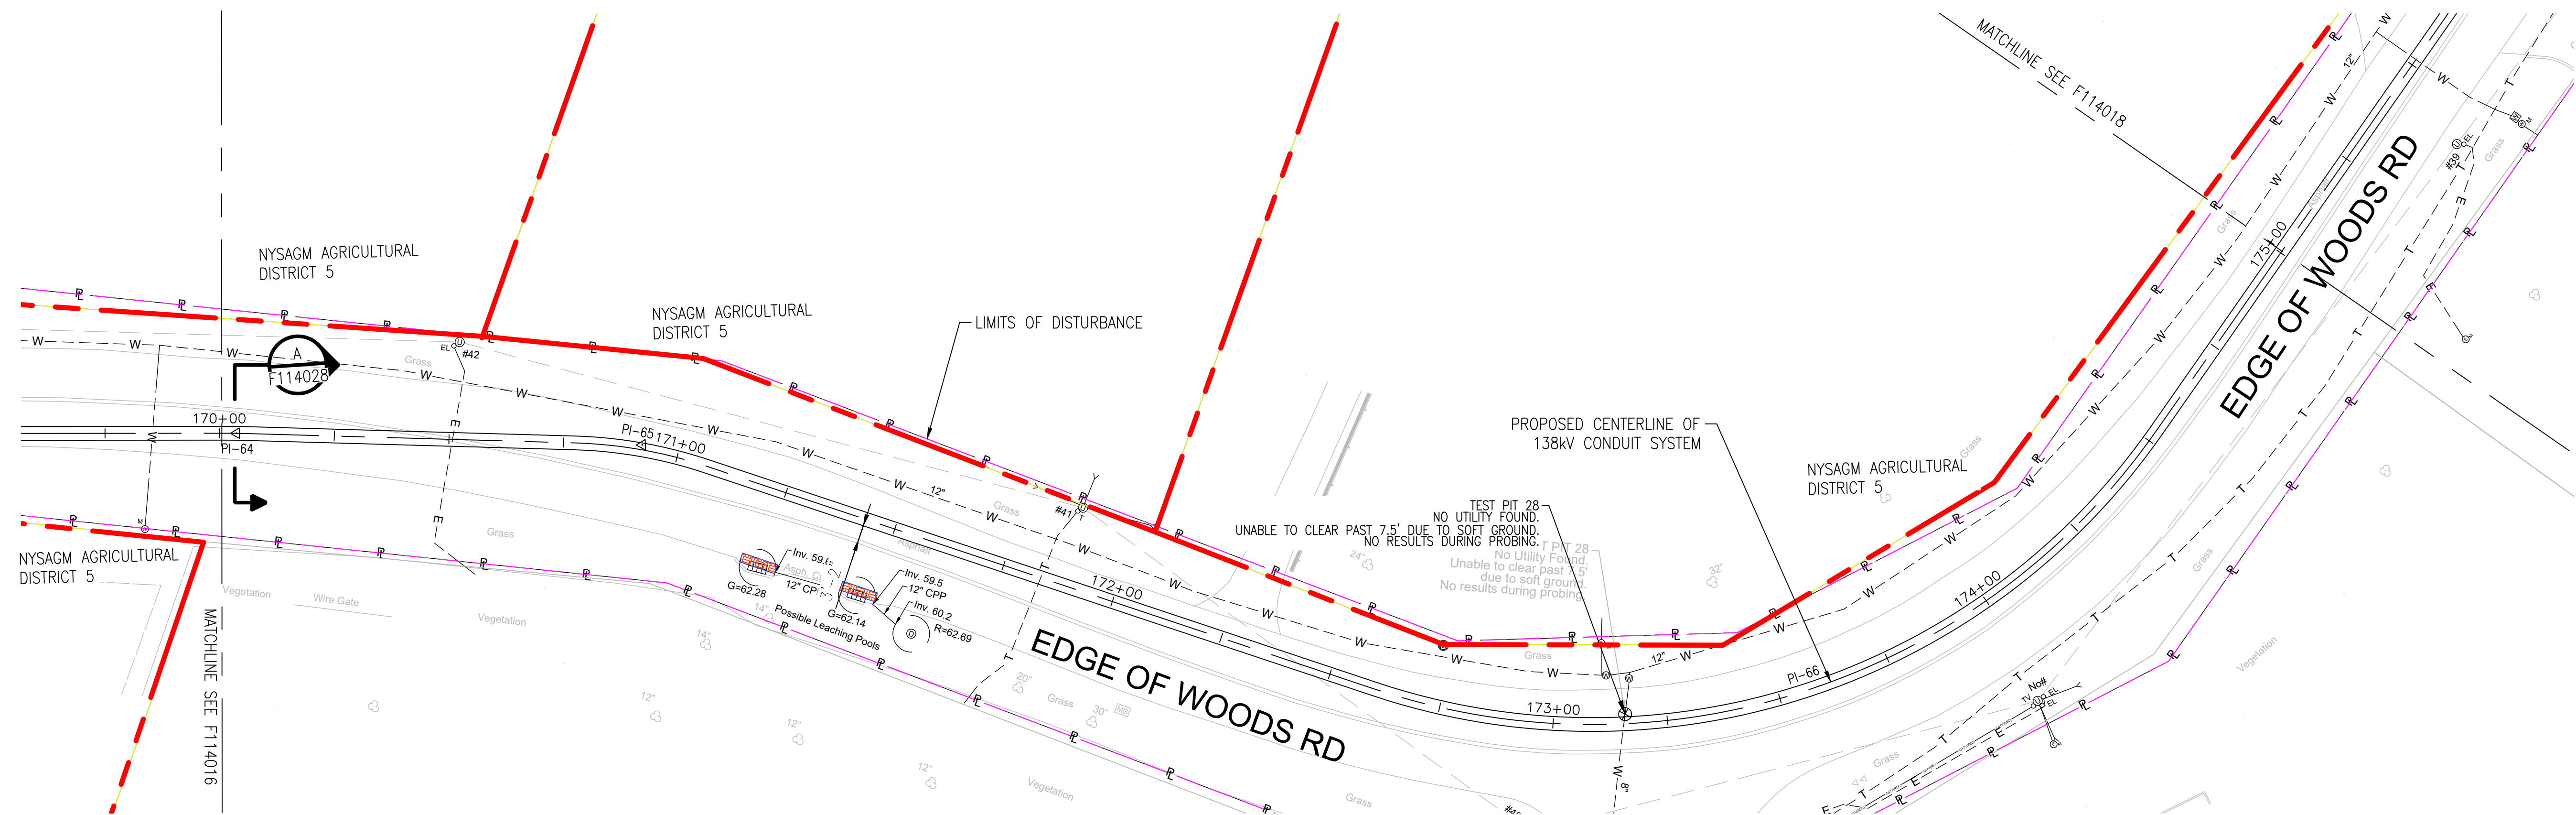

APPROVED WITH
CORRECTIONS AS NOTED
PSEG Long Island

THIS APPROVAL SHALL NOT RELIEVE THE CONTRACTOR FROM ENTIRE RESPONSIBILITY FOR DIMENSIONAL ACCURACY, CONFORMANCE WITH REFERENCED SPECIFICATIONS, CODES AND ALL LIABILITY UNDER CONTRACT.


PER: _____
DATE: _____

NOTES:

1. SEE F113982 AND F113983 FOR ROUTE DATA TABLE AND PULLING CALCULATIONS.

IT IS A VIOLATION OF THE PROFESSIONAL LICENSE LAW FOR ANY PERSON TO ALTER THIS DRAWING IN ANY WAY, UNLESS ACTING UNDER THE DIRECTION OF A LICENSED PROFESSIONAL ENGINEER. THE ALTERING CONSULTANT SHALL AFFIX THEIR SEAL AND THE NOTATION "ALTERED BY" FOLLOWED BY THEIR SIGNATURE AND DATE OF ALTERATION.

ISSUED
FOR PERMITTING

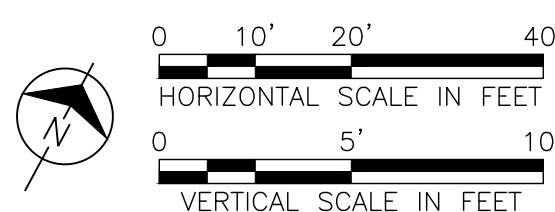[illegible]



**BURNS
MCDONNELL**

PROJ. NO.	154527
-----------	--------

ISSUE								
	10/10/2024	L30101	GENERAL ISSUE		IS	EX	IF WORKED FE	IF WORKED FE
	NO.	DATE	W.O.	DESCRIPTION	DWN BY	CWD BY	REVIEWED	APPO

 Long Island Power Authority TIANA BUELL OPS BLDG 1 69KV TRANSMISSION LINE			
PLAN AND PROFILE SHEET 33 OF 47 SOUTHAMPTON TO DEERFIELD 138KV OPERATED AT 69KV UNDERGROUND TRANSMISSION ENGINEERING			
 PSEG LONG ISLAND 175 East Old Country Road Hicksville, New York			
SCALE HORIZ: 1"=20' VERT: 1"=5'		VENDOR DWG. NO.	
DRAWING NO. F114017	SMART NO. RVF69-FU-01190		REVISION 0
SYSTEM GRID NUMBER	CABINET NO.		FOLDER NO.

A
B
C
D
E
F

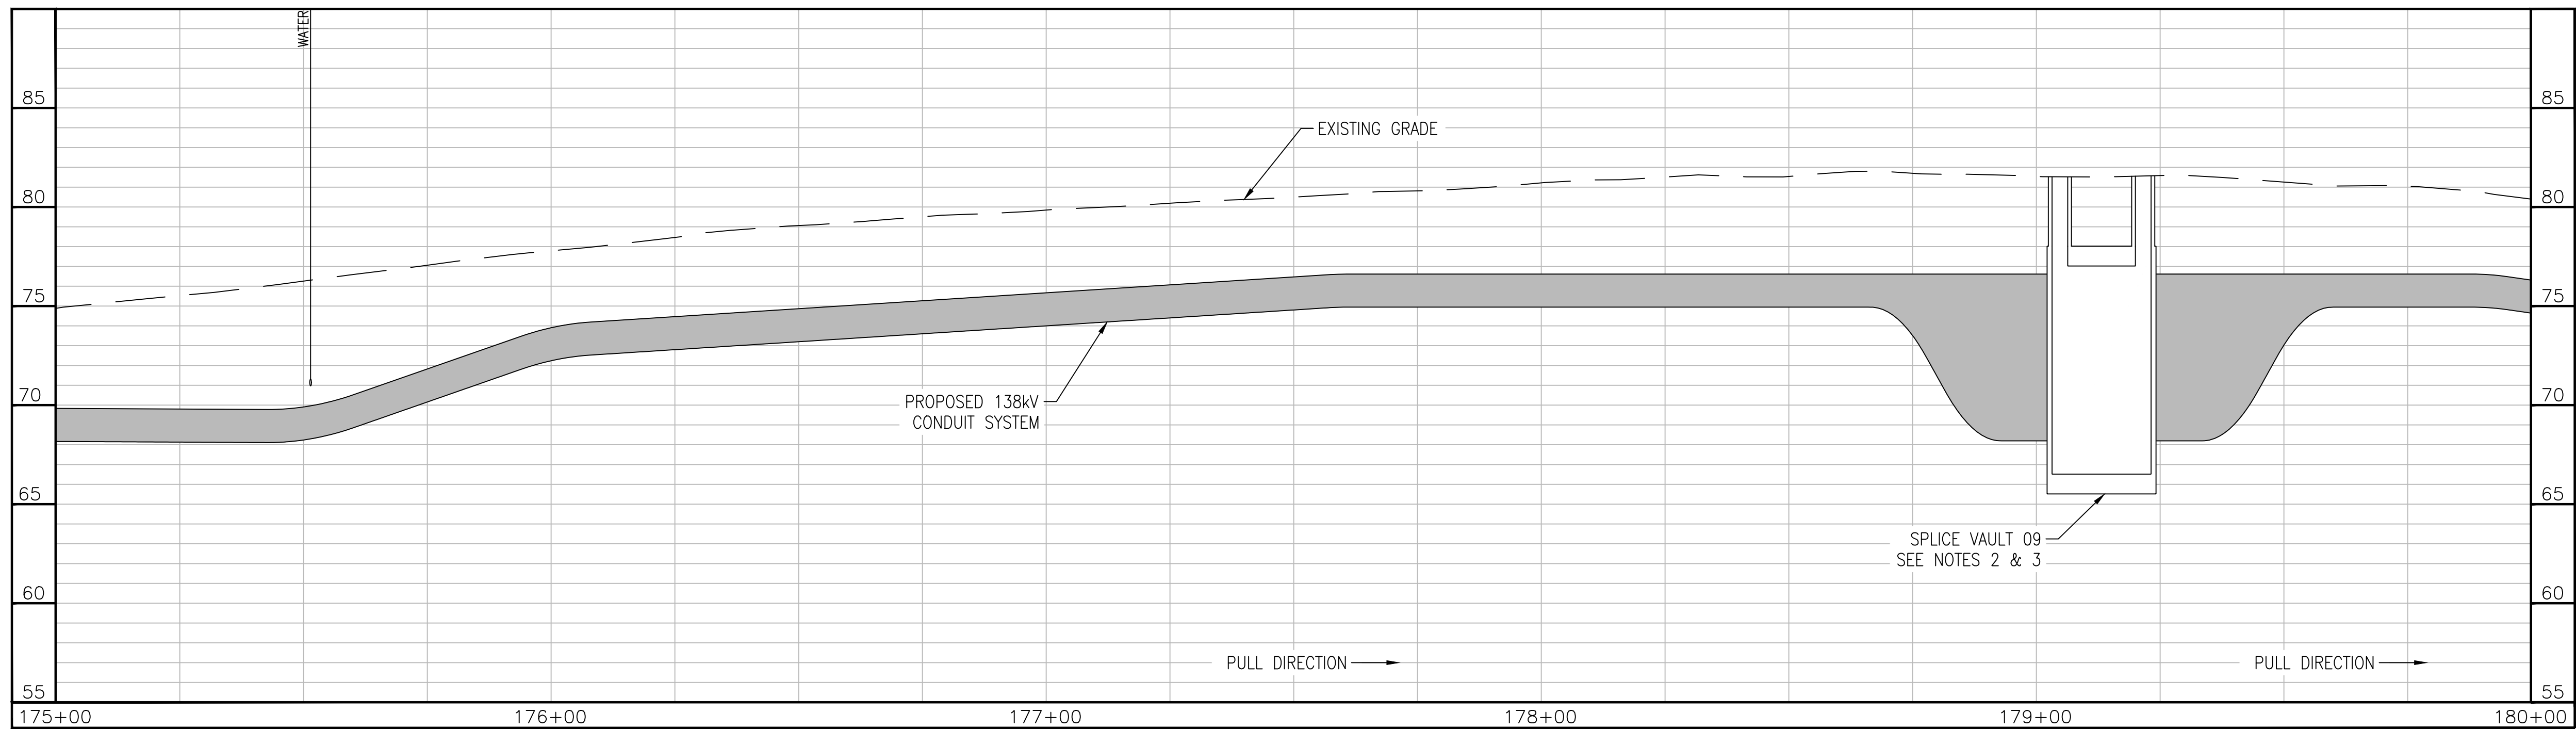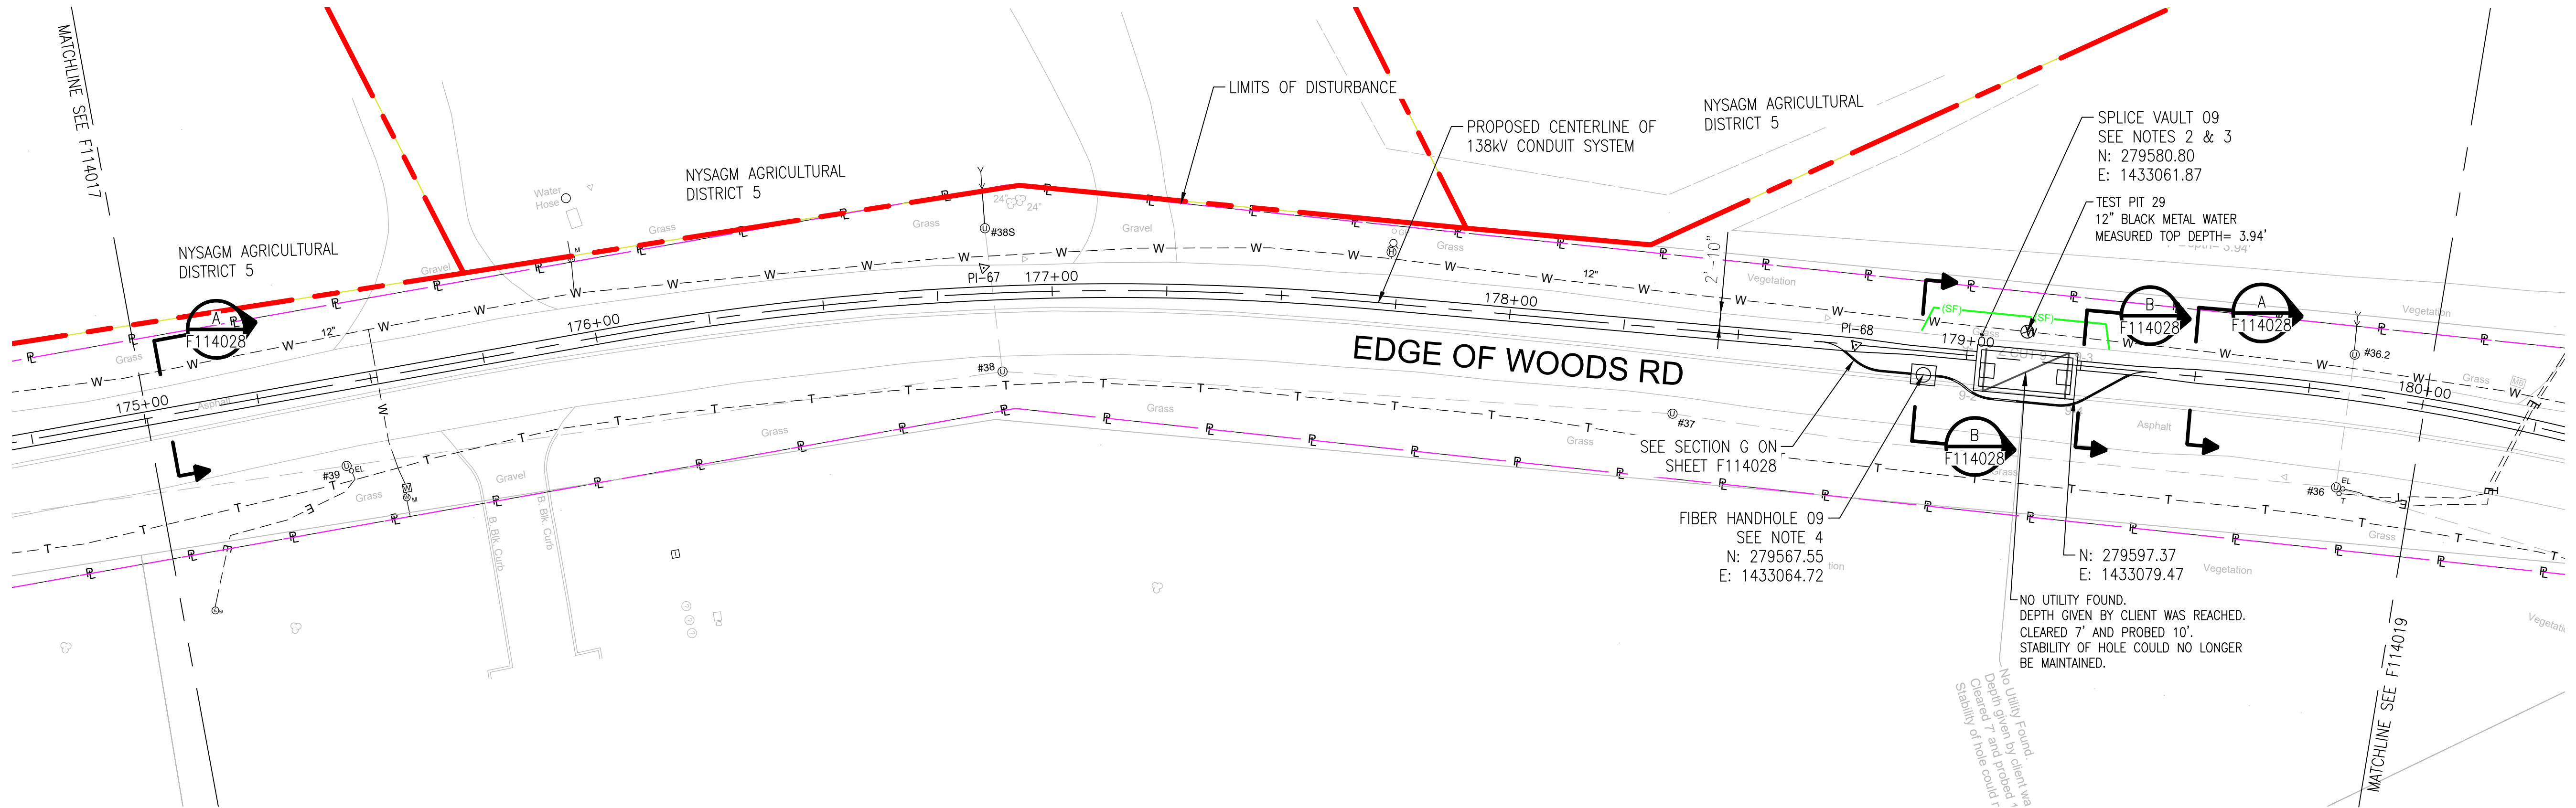

APPROVED WITH
CORRECTIONS AS NOTED
PSEG Long Island


THIS APPROVAL SHALL NOT RELIEVE
THE CONTRACTOR FROM ENTIRE
RESPONSIBILITY FOR DIMENSIONAL
ACCURACY, CONFORMANCE WITH
REFERENCED SPECIFICATIONS, CODES
AND ALL LIABILITY UNDER CONTRACT.

PER: _____
DATE: _____

NOTES:

1. SEE F113982 AND F113983 FOR ROUTE DATA TABLE AND PULLING CALCULATIONS.
2. SEE F114522, F114550 AND F114556 THROUGH F114558 FOR SPLICE VAULT DETAILS.
3. SPLICE VAULT DESIGN TO BE CONFIRMED BY PSEG LONG ISLAND IN SUBSEQUENT STAGES OF DESIGN.
4. SEE F114031 FOR FIBER HANDHOLE DETAILS.

IT IS A VIOLATION OF THE PROFESSIONAL LICENSE LAW
FOR ANY PERSON TO ALTER THIS DRAWING IN ANY WAY,
UNLESS ACTING UNDER THE DIRECTION OF A LICENSED
PROFESSIONAL ENGINEER. THE ALTERING CONSULTANT
SHALL AFFIX THEIR SEAL AND THE NOTATION "ALTERED BY"
FOLLOWED BY THEIR SIGNATURE AND DATE OF ALTERATION.

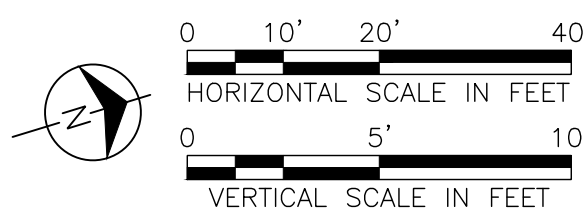

ISSUED
FOR PERMITTING

REV	DATE	DESCRIPTION	DRAWN	REVIEW	APPR
0	10/03/2025	ISSUED FOR PERMITTING	JAS	LAF	DAG
0	07/25/2025	ISSUED FOR CONSTRUCTION	JAS	LAF	DAG

**BURNS
MEDONNELL**

PROJ. NO. 154527

NO.	DATE	W.O.	DESCRIPTION	ISSUE	ISSUED BY	CHK BY	REVISED BY	REVISED DATE	APPROVED BY
1	10/03/2025	L8910	ISSUED FOR PERMITTING	AS	KT	KT	KT	KT	KT

Long Island Power Authority
TIANA - BUELL
OPS BLDG 1
69kV TRANSMISSION LINE

PLAN AND PROFILE SHEET 34 OF 47
SOUTHAMPTON TO DEERFIELD 138kV OPERATED AT 69kV
UNDERGROUND TRANSMISSION ENGINEERING



PSEG LONG ISLAND
175 East Old Country Road
Hicksville, New York

SCALE
HORIZ: 1"=20' VERT: 1"=5'

DRAWING NO. F114018
VENDOR DWG. NO. RVF69-FU-01191
REVISION 0

SYSTEM GRID NUMBER
CABINET NO.
FOLDER NO.

A
B
C
D
E
F

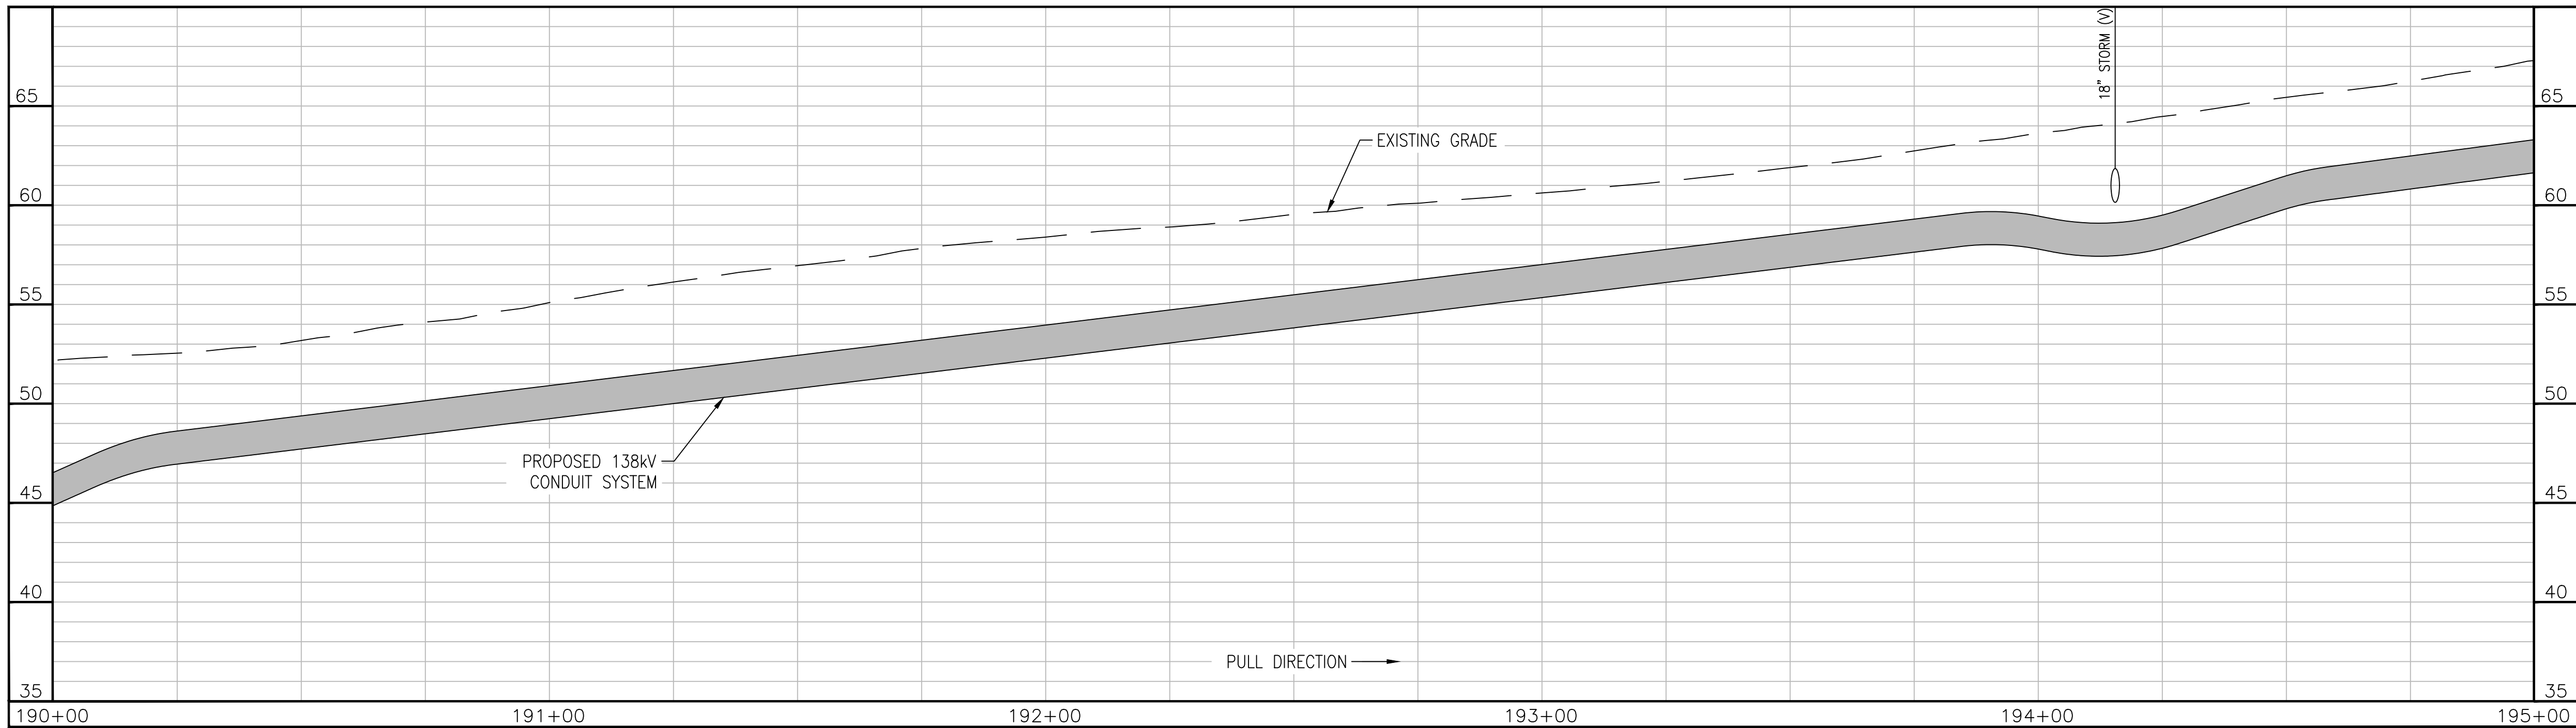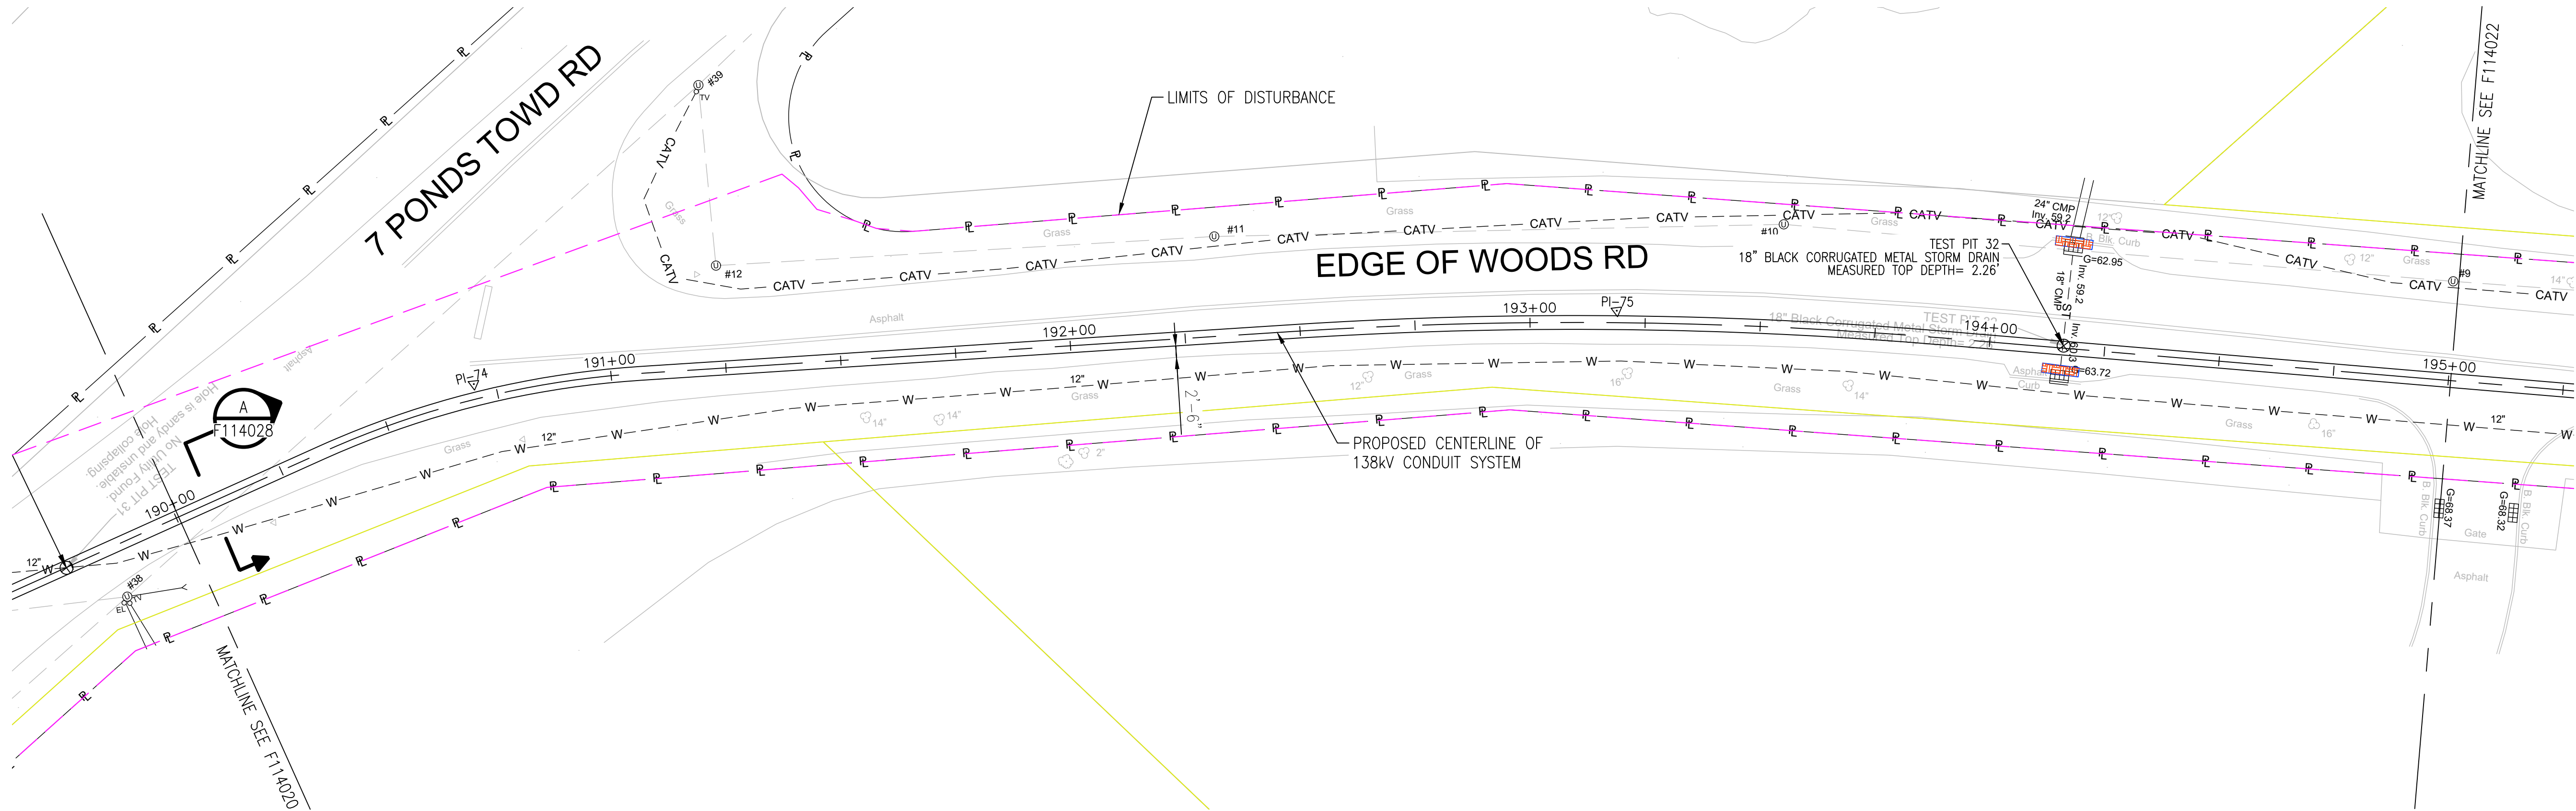


APPROVED WITH
CORRECTIONS AS NOTED
PSEG Long Island

THIS APPROVAL SHALL NOT RELIEVE
THE CONTRACTOR FROM ENTIRE
RESPONSIBILITY FOR DIMENSIONAL
ACCURACY, CONFORMANCE WITH
REFERENCED SPECIFICATIONS, CODES
AND ALL LIABILITY UNDER CONTRACT.

PER: _____
DATE: _____

NOTES:
1. SEE F113982 AND F113983 FOR ROUTE DATA TABLE AND PULLING CALCULATIONS.

IT IS A VIOLATION OF THE PROFESSIONAL LICENSE LAW
FOR ANY PERSON TO ALTER THIS DRAWING IN ANY WAY,
UNLESS ACTING UNDER THE DIRECTION OF A LICENSED
PROFESSIONAL ENGINEER. THE ALTERING CONSULTANT
SHALL AFFIX THEIR SEAL AND THE NOTATION "ALTERED BY"
FOLLOWED BY THEIR SIGNATURE AND DATE OF ALTERATION.

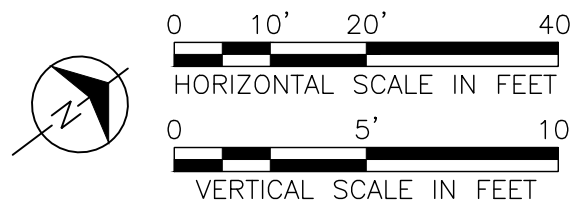

ISSUED
FOR PERMITTING

NO.	DATE	W.O.	DESCRIPTION	DWN BY	CHK BY	REVISED	BY	DATE
0	10/03/2025		ISSUED FOR PERMITTING	JAS	LAF	DAG		
0	07/25/2025		ISSUED FOR CONSTRUCTION	JAS	LAF	DAG		
REV	DATE		DESCRIPTION	DRAWN	REVIEW	APPR		

BURNS
MEDONNELL

PROJ. NO. 154527

NO.	DATE	W.O.	DESCRIPTION	DWN BY	CHK BY	REVISED	BY	DATE
0	10/03/2025		ISSUED FOR PERMITTING	JAS	LAF	DAG		
0	07/25/2025		ISSUED FOR CONSTRUCTION	JAS	LAF	DAG		
REV	DATE		DESCRIPTION	DRAWN	REVIEW	APPR		

Long Island Power Authority
TIANA - BUELL
OPS BLDG 1
69kV TRANSMISSION LINE

PLAN AND PROFILE SHEET 37 OF 47
SOUTHAMPTON TO DEERFIELD 138kV OPERATED AT 69kV
UNDERGROUND TRANSMISSION ENGINEERING



PSEG LONG ISLAND
175 East Old Country Road
Hicksville, New York

SCALE
HORIZ: 1"=20' VERT: 1"=5'

DRAWING NO. F114021
VENDOR DWG. NO. RVF69-FU-01194
REVISION 0

SYSTEM ORG. NUMBER
CABINET NO.
FOLDER NO.

A
B
C
D
E
F

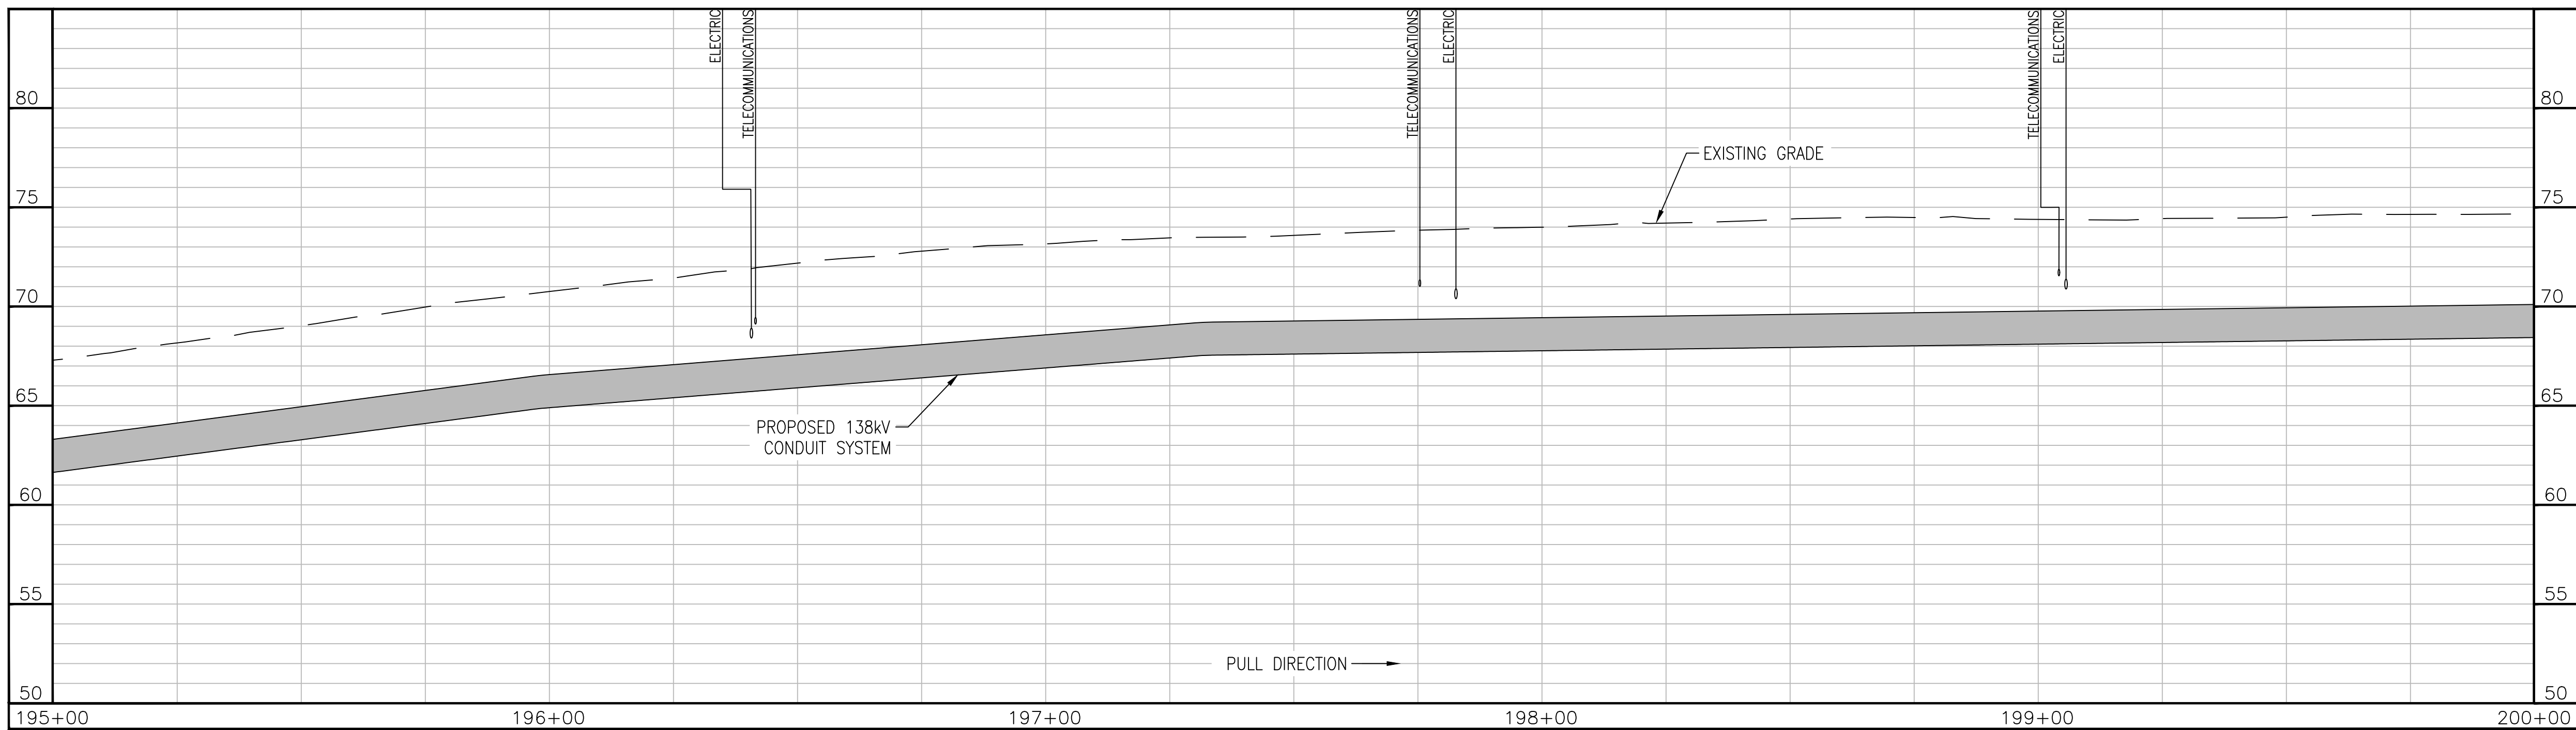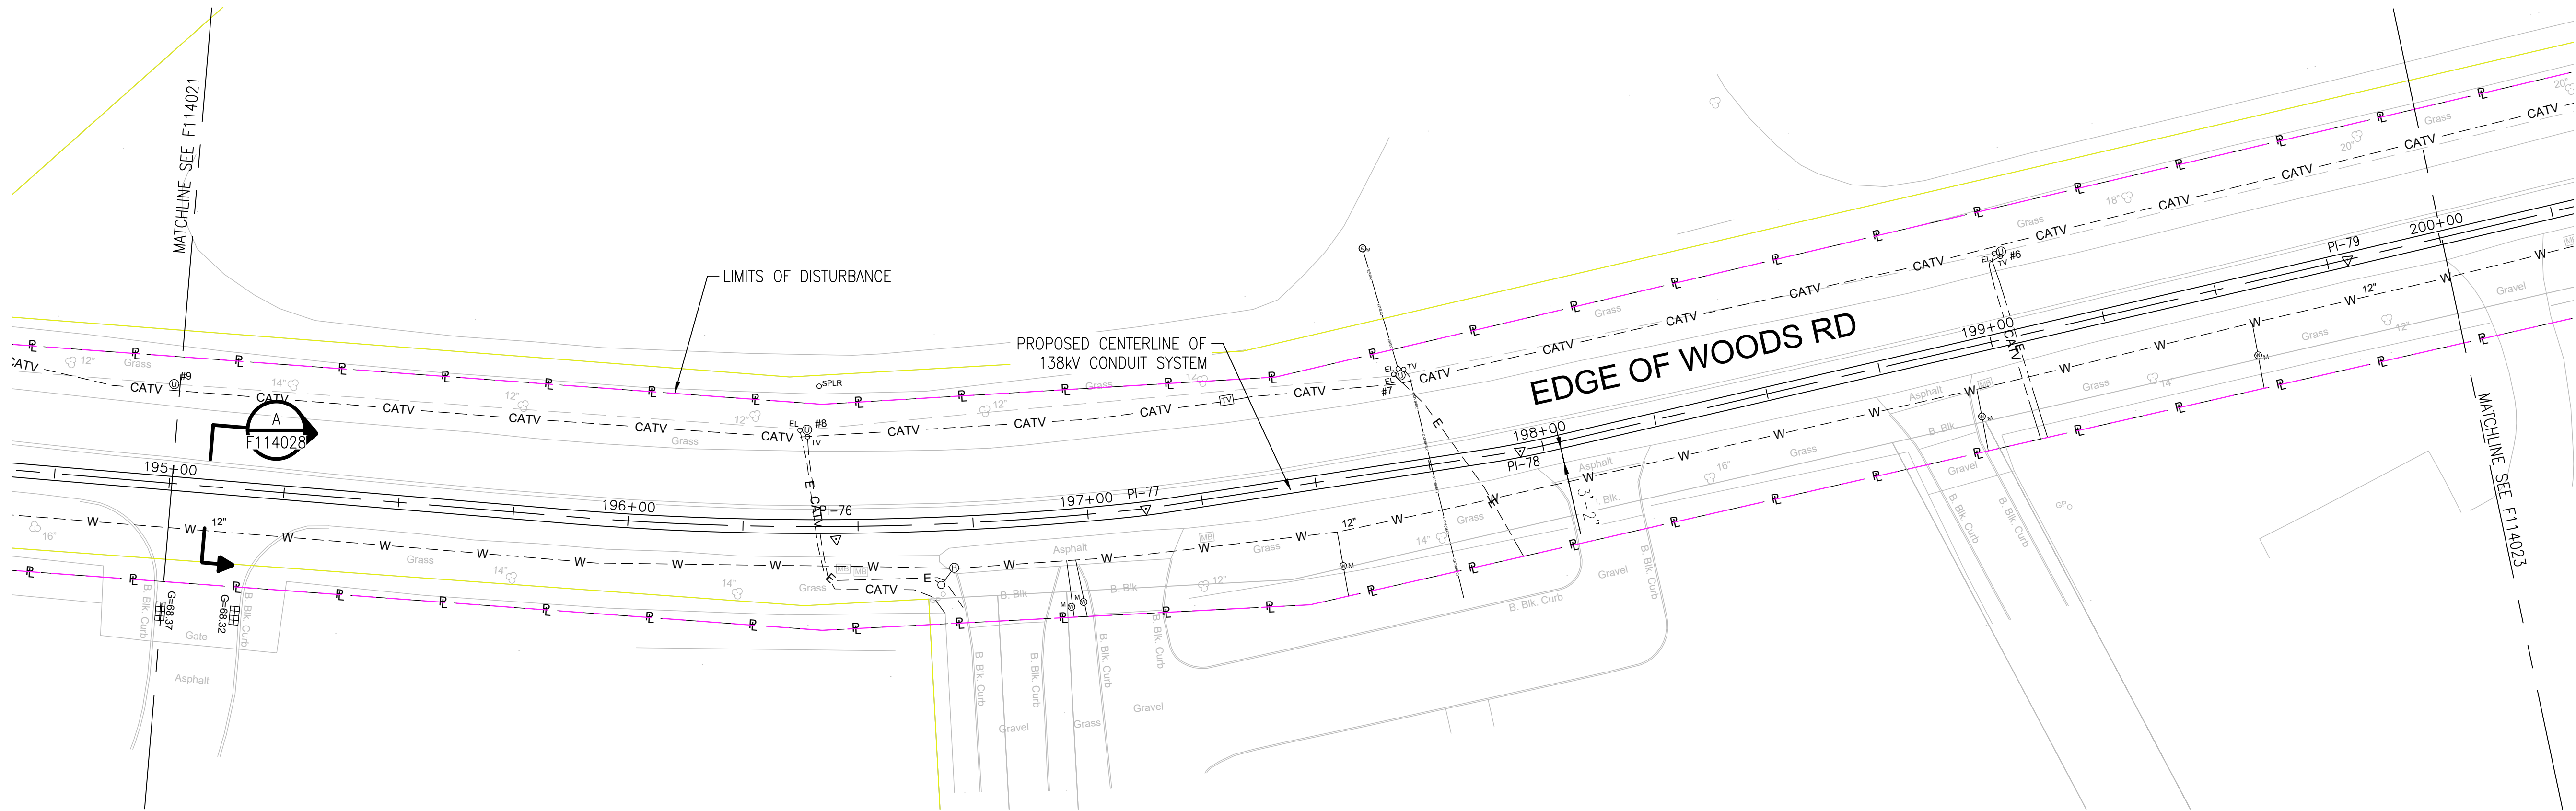


APPROVED WITH
CORRECTIONS AS NOTED
PSEG Long Island

THIS APPROVAL SHALL NOT RELIEVE
THE CONTRACTOR FROM ENTIRE
RESPONSIBILITY FOR DIMENSIONAL
ACCURACY, CONFORMANCE WITH
REFERENCED SPECIFICATIONS, CODES
AND ALL LIABILITY UNDER CONTRACT.

PER: _____
DATE: _____

NOTES:
1. SEE F113982 AND F113983 FOR ROUTE DATA TABLE AND PULLING CALCULATIONS.

IT IS A VIOLATION OF THE PROFESSIONAL LICENSE LAW
FOR ANY PERSON TO ALTER THIS DRAWING IN ANY WAY,
UNLESS ACTING UNDER THE DIRECTION OF A LICENSED
PROFESSIONAL ENGINEER. THE ALTERING CONSULTANT
SHALL AFFIX THEIR SEAL AND THE NOTATION "ALTERED BY"
FOLLOWED BY THEIR SIGNATURE AND DATE OF ALTERATION.

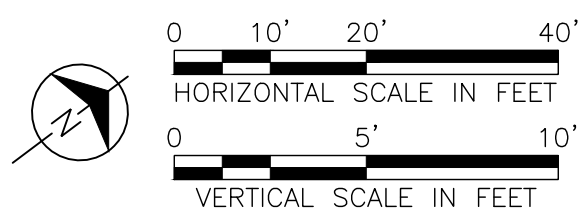

ISSUED
FOR PERMITTING

NO.	DATE	DESCRIPTION	DWN BY	CHK BY	REVISED	APPR
0	10/03/2025	ISSUED FOR PERMITTING	JAS	LAF	DAG	
0	07/25/2025	ISSUED FOR CONSTRUCTION	JAS	LAF	DAG	

**BURNS
MEDONNELL**

PROJ. NO. 154527

NO.	DATE	W.O.	DESCRIPTION	DWN BY	CHK BY	REVISED	APPR
1	10/01/2024	L8910	ORINAL ISSUE				

Long Island Power Authority
TIANA - BUELL
OPS BLDG 1
69KV TRANSMISSION LINE

PLAN AND PROFILE SHEET 38 OF 47
SOUTHAMPTON TO DEERFIELD 138KV OPERATED AT 69KV
UNDERGROUND TRANSMISSION ENGINEERING

PSEG LONG ISLAND
175 East Old Country Road
Hicksville, New York

SCALE
HORIZ: 1"=20' VERT: 1"=5'

DRAWING NO. F114022
VENDOR DWG. NO. RVF69-FU-01195
SMART NO. 0

SYSTEM ORG. NUMBER
CABINET NO.
FOLDER NO.

A



B

C

D

E

F

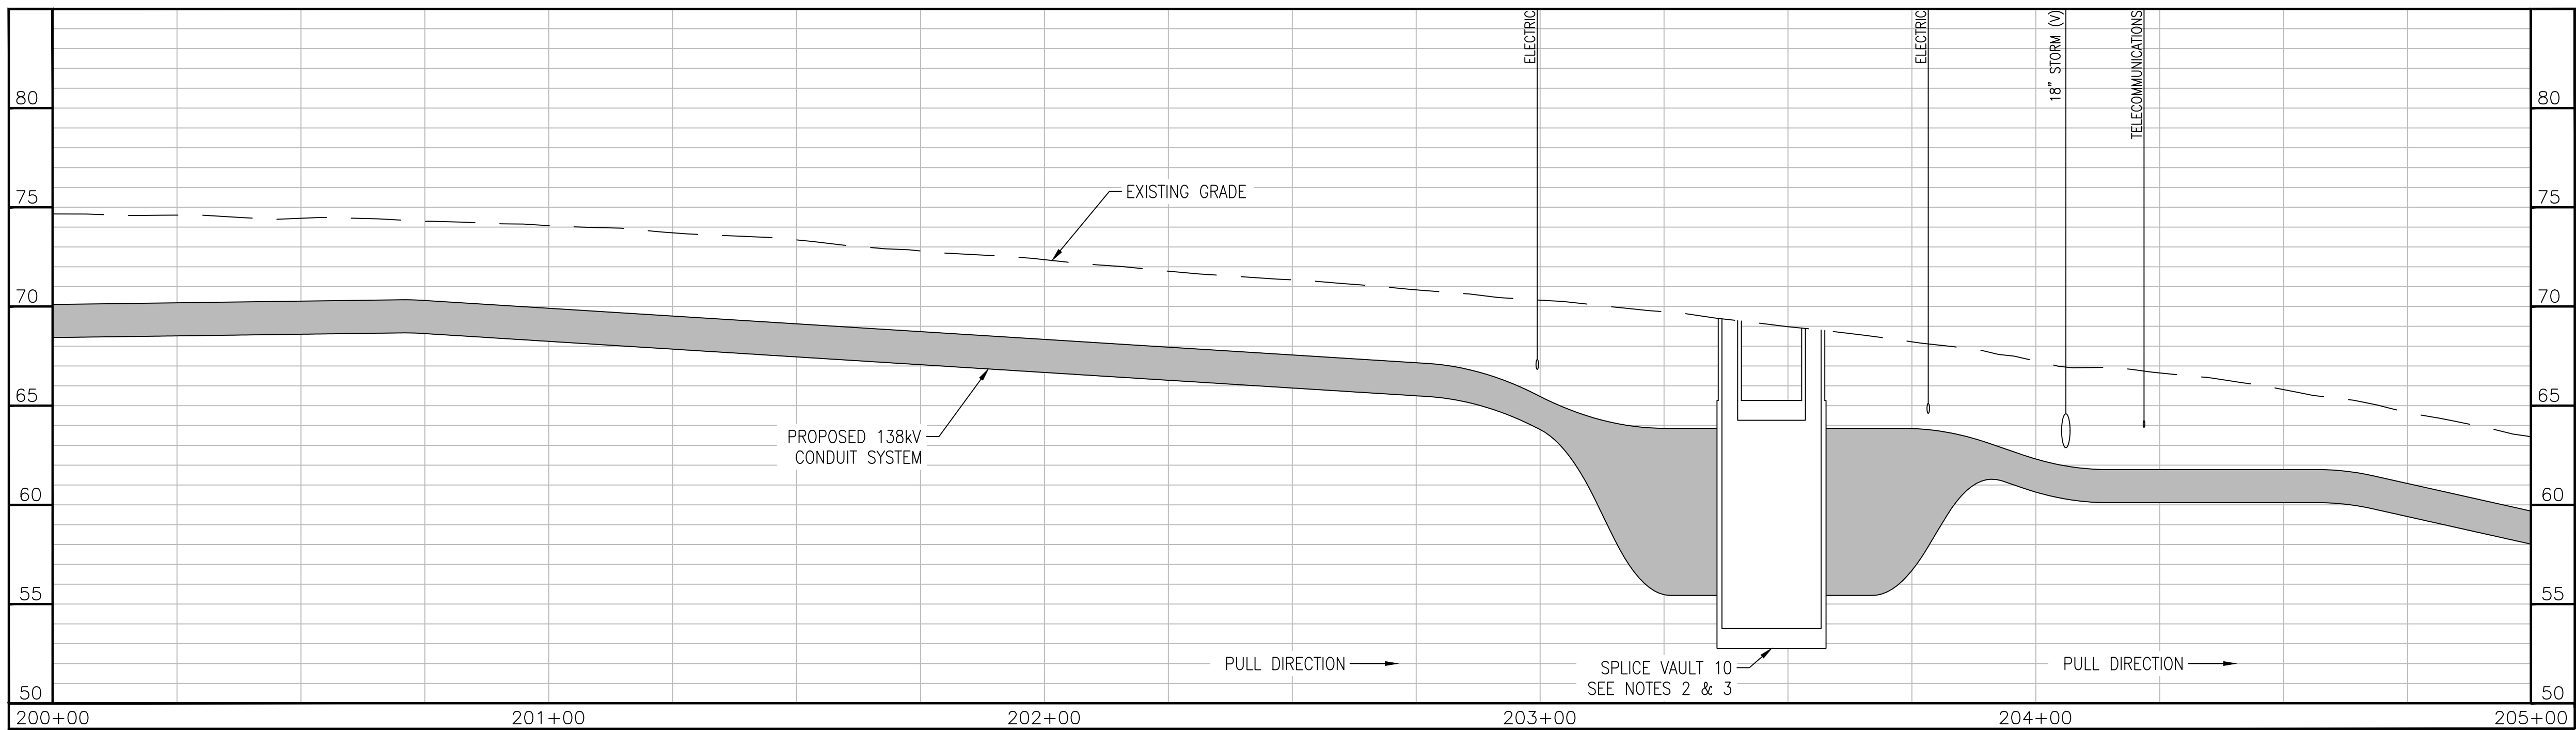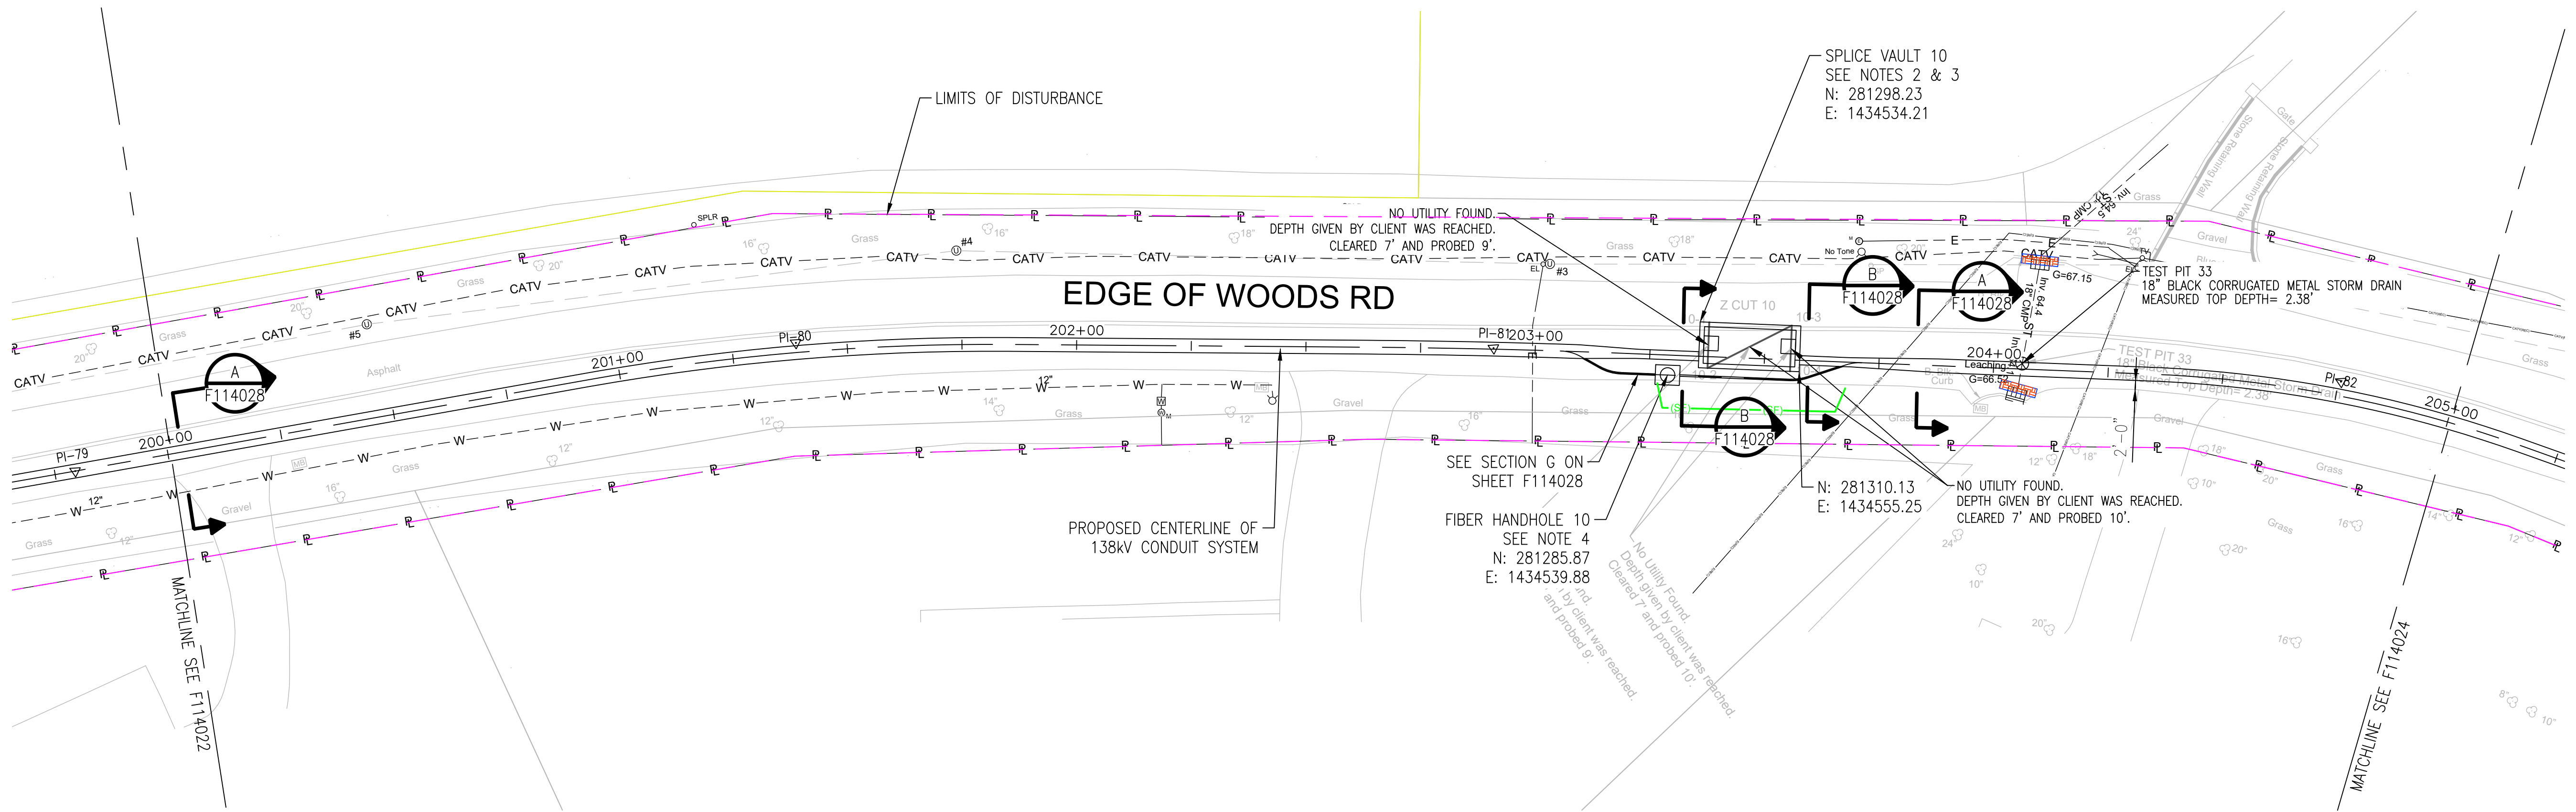

APPROVED WITH
CORRECTIONS AS NOTED
PSEG Long Island


THIS APPROVAL SHALL NOT RELIEVE
THE CONTRACTOR FROM ENTIRE
RESPONSIBILITY FOR DIMENSIONAL
ACCURACY, CONFORMANCE WITH
REFERENCED SPECIFICATIONS, CODES
AND ALL LIABILITY UNDER CONTRACT.

PER: _____
DATE: _____

NOTES:

- SEE F113982 AND F113983 FOR ROUTE DATA TABLE AND PULLING CALCULATIONS.
- SEE F114522, F114550 AND F114556 THROUGH F114558 FOR SPLICE VAULT DETAILS.
- SPLICE VAULT DESIGN TO BE CONFIRMED BY PSEG LONG ISLAND IN SUBSEQUENT STAGES OF DESIGN.
- SEE F114031 FOR FIBER HANDHOLE DETAILS.

IT IS A VIOLATION OF THE PROFESSIONAL LICENSE LAW
FOR ANY PERSON TO ALTER THIS DRAWING IN ANY WAY,
UNLESS ACTING UNDER THE DIRECTION OF A LICENSED
PROFESSIONAL ENGINEER. THE ALTERING CONSULTANT
SHALL AFFIX THEIR SEAL AND THE NOTATION "ALTERED BY"
FOLLOWED BY THEIR SIGNATURE AND DATE OF ALTERATION.

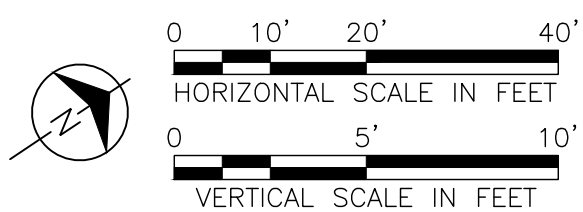

ISSUED
FOR PERMITTING


REV	DATE	DESCRIPTION	DRAWN	REVIEW	APPR
0	10/03/2025	ISSUED FOR PERMITTING	JAS	LAF	DAG
0	07/25/2025	ISSUED FOR CONSTRUCTION	JAS	LAF	DAG

**BURNS
MEDONNELL**

PROJ. NO. 154527


NO.	DATE	W.O.	DESCRIPTION	OWN BY	CHK BY	REVISED	BY	DATE	BY	DATE
1	10/03/2025	LBN	DRWG ISSUE							

Long Island Power Authority TIANA - BUELL OPS BLDG 1 69kV TRANSMISSION LINE	
PLAN AND PROFILE SHEET 39 OF 47 SOUTHAMPTON TO DEERFIELD 138kV OPERATED AT 69kV UNDERGROUND TRANSMISSION ENGINEERING	
PSEG LONG ISLAND 175 East Old Country Road Hicksville, New York	
DRAWING NO. F114023	SMART NO. RVF69-FU-01196
SYSTEM GRID NUMBER	FOLDER NO.

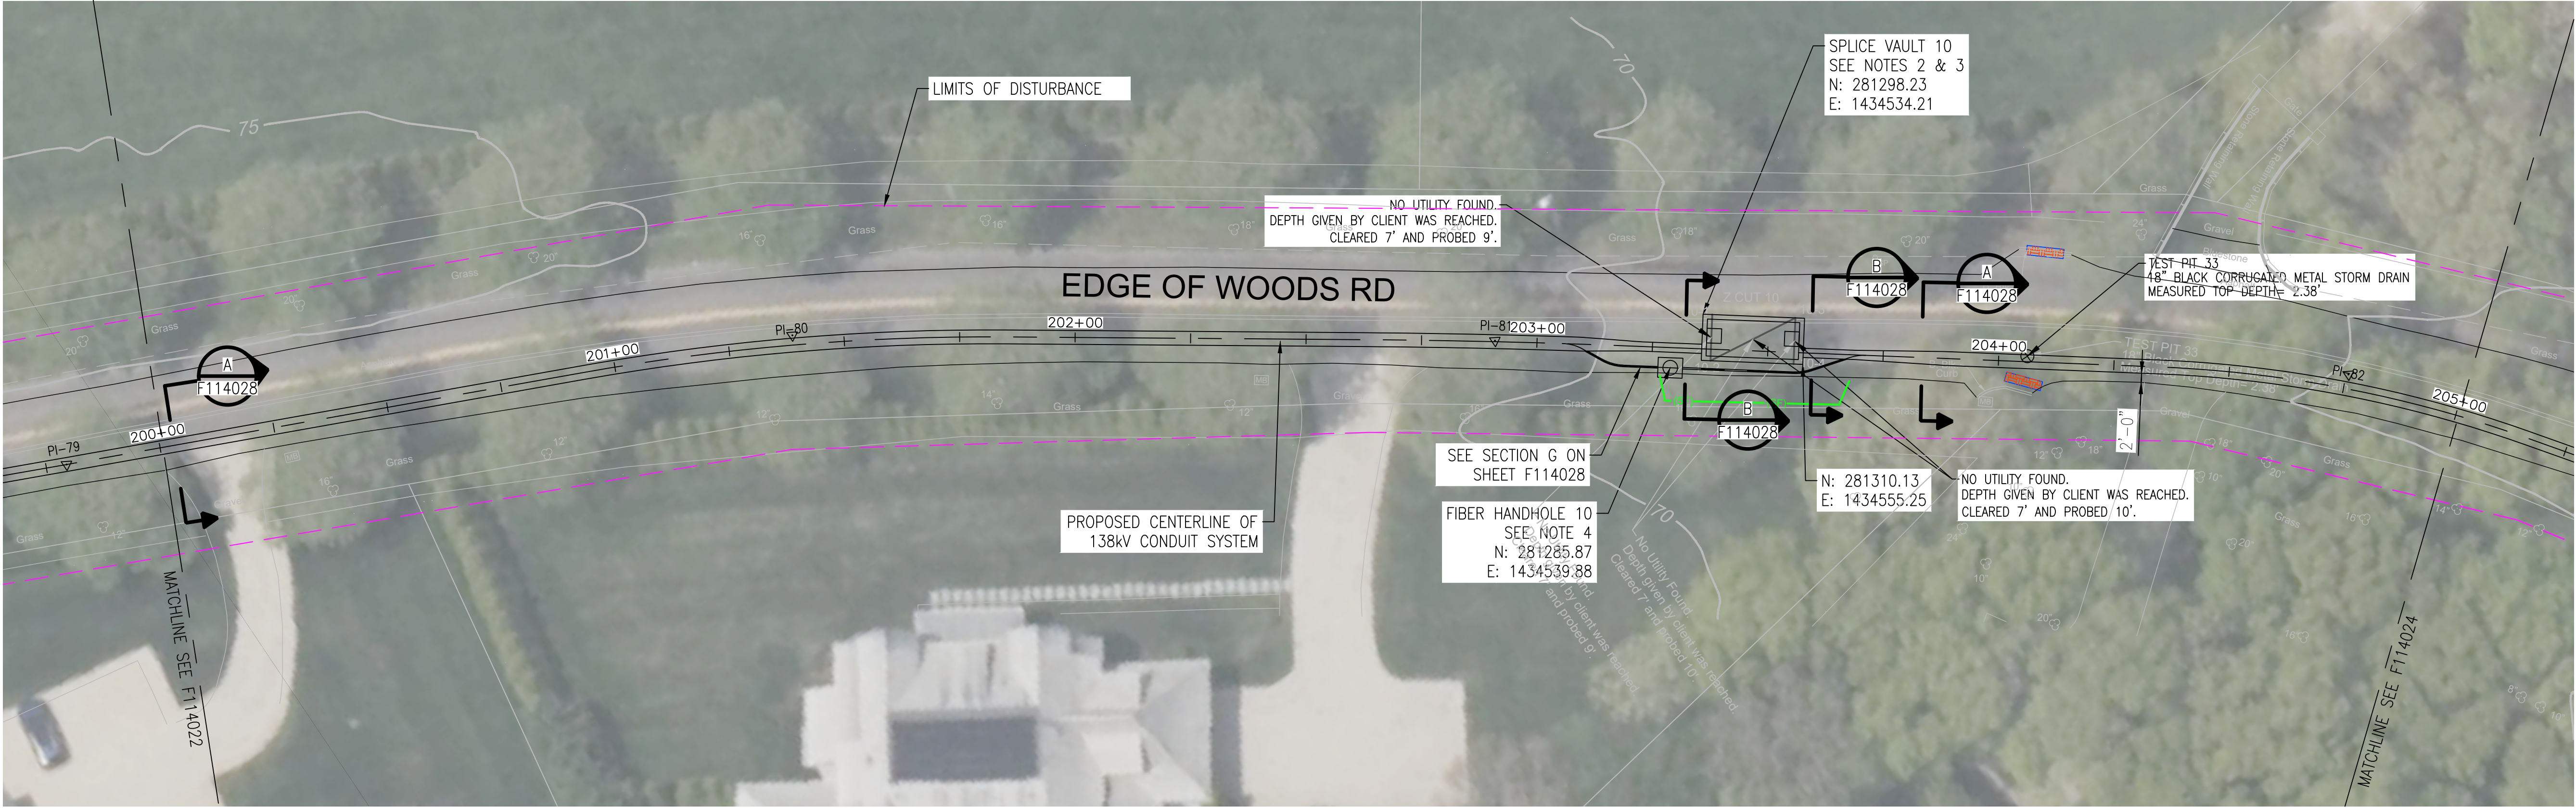

- NOTES:
- SEE F113982 AND F113983 FOR ROUTE DATA TABLE AND PULLING CALCULATIONS.
 - SEE F114522, F114550 AND F114556 THROUGH F114558 FOR SPLICE VAULT DETAILS.
 - SPLICE VAULT DESIGN TO BE CONFIRMED BY PSEG LONG ISLAND IN SUBSEQUENT STAGES OF DESIGN.
 - SEE F114031 FOR FIBER HANDHOLE DETAILS.

IT IS A VIOLATION OF THE PROFESSIONAL LICENSE LAW FOR ANY PERSON TO ALTER THIS DRAWING IN ANY WAY, UNLESS ACTING UNDER THE DIRECTION OF A LICENSED PROFESSIONAL ENGINEER. THE ALTERING CONSULTANT SHALL AFFIX THEIR SEAL AND THE NOTATION "ALTERED BY" FOLLOWED BY THEIR SIGNATURE AND DATE OF ALTERATION.

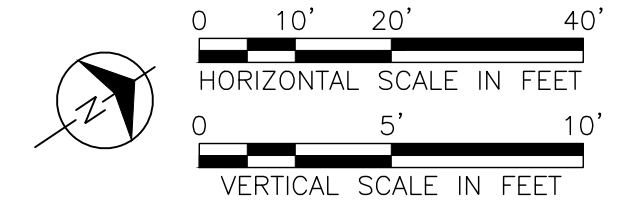

ISSUED
FOR PERMITTING

0 10/03/2025 ISSUED FOR PERMITTING JAS LAF DAG		0 07/25/2025 ISSUED FOR CONSTRUCTION JAS LAF DAG		0 10/03/2025 ISSUED FOR PERMITTING JAS LAF DAG		0 07/25/2025 ISSUED FOR CONSTRUCTION JAS LAF DAG		0 10/03/2025 ISSUED FOR PERMITTING JAS LAF DAG		0 07/25/2025 ISSUED FOR CONSTRUCTION JAS LAF DAG			
REV	DATE	DESCRIPTION	DRAWN	REVIEW	APPR	NO.	DATE	W.O.	DESCRIPTION	DWN BY	CKD BY	REVISED	APPR
PROJ. NO. 154527													

Long Island Power Authority TIANA - BUELL OPS BLDG 1 69kV TRANSMISSION LINE											
PLAN AND PROFILE SHEET 39 OF 47 SOUTHAMPTON TO DEERFIELD 138kV OPERATED AT 69kV UNDERGROUND TRANSMISSION ENGINEERING											
PSEG LONG ISLAND 175 East Old Country Road Hicksville, New York											
SCALE HORIZ: 1"=20' VERT: 1"=5'											
VENDOR DWG. NO.											
DRAWING NO. F114023i											
SMART NO. RVF69-FU-01196											
REVISION 0											
SYSTEM ORD. NUMBER											
CABINET NO.											
FOLDER NO.											

A



B

C

D

E

F

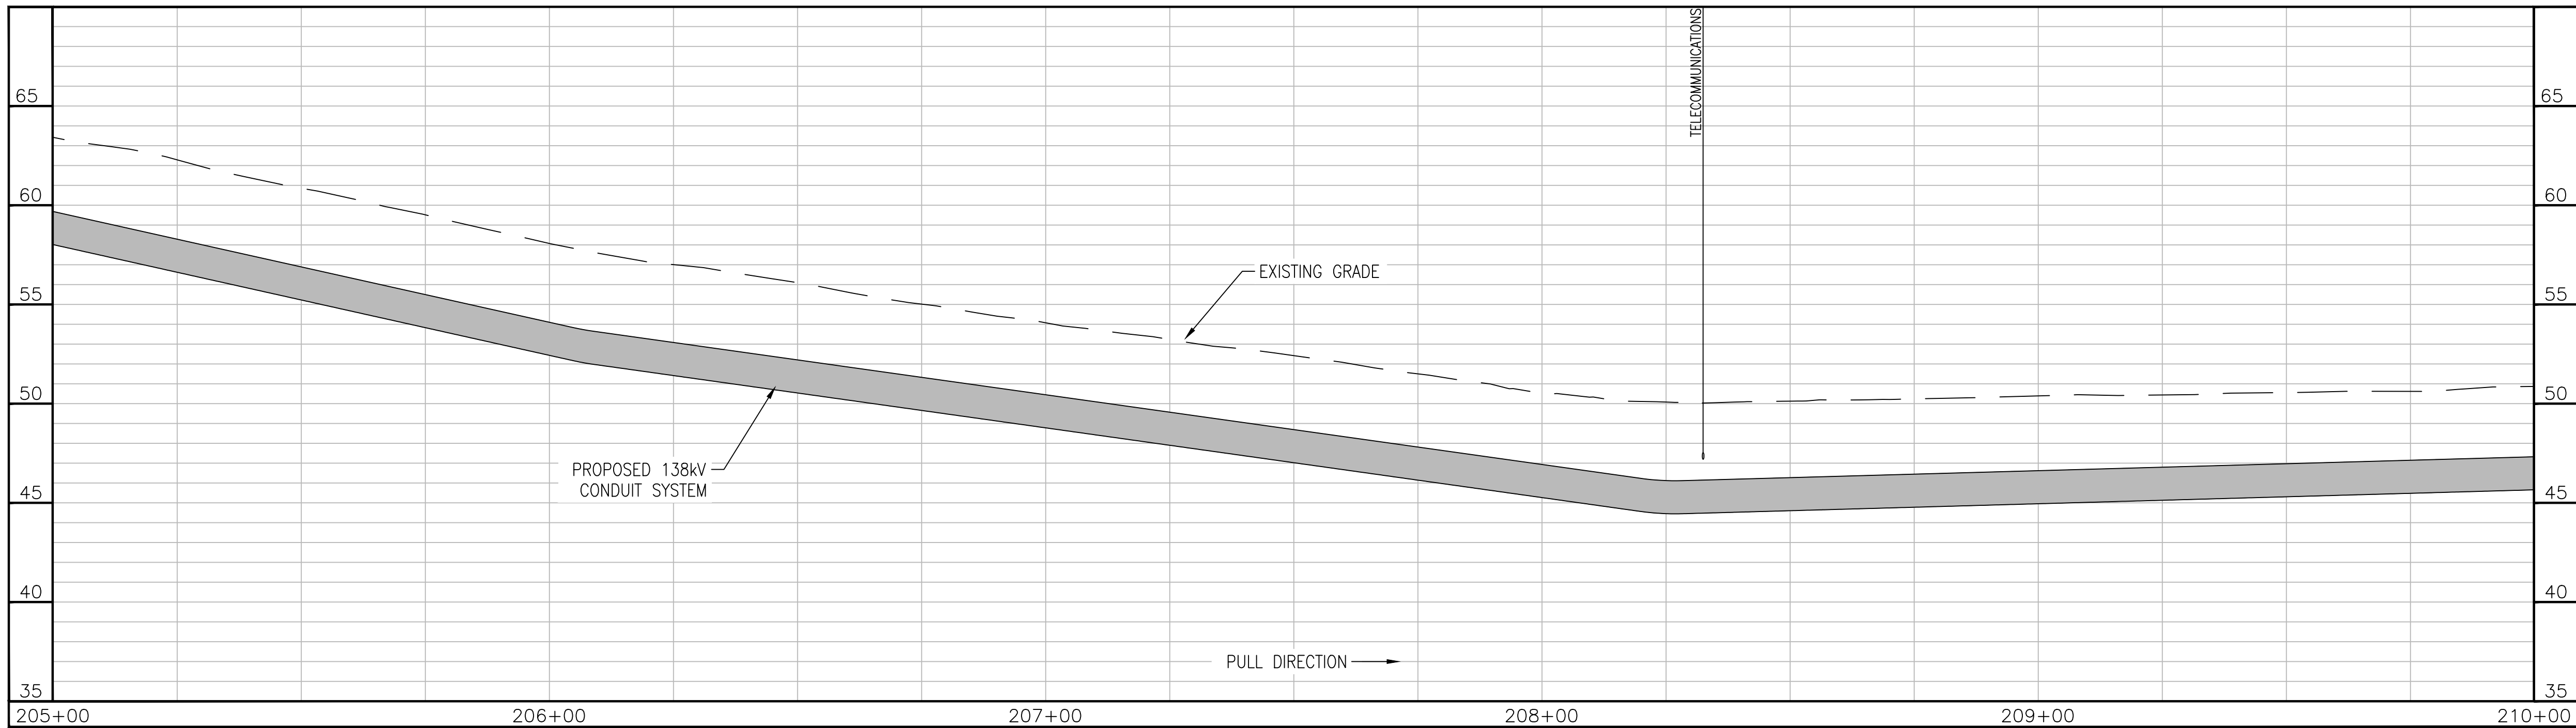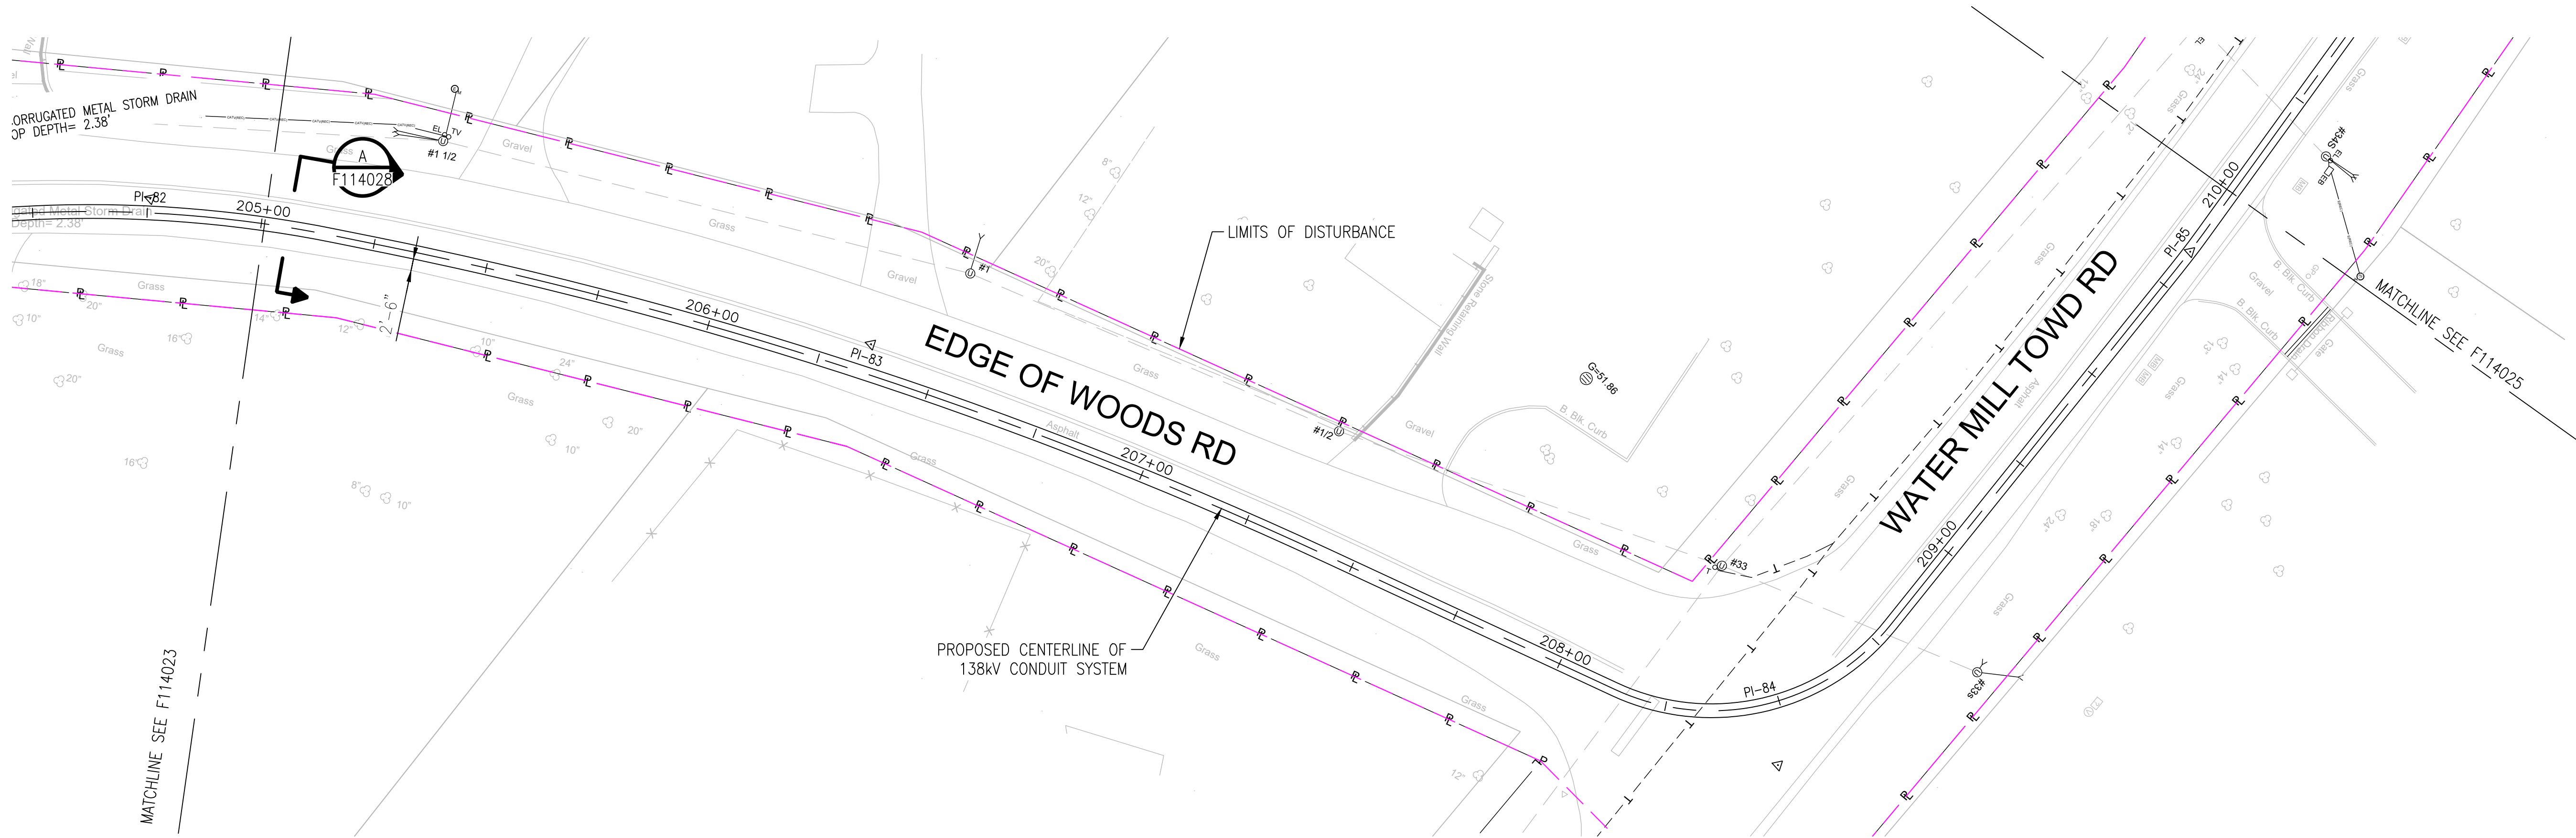

APPROVED WITH
CORRECTIONS AS NOTED
PSEG Long Island

THIS APPROVAL SHALL NOT RELIEVE
THE CONTRACTOR FROM ENTIRE
RESPONSIBILITY FOR DIMENSIONAL
ACCURACY, CONFORMANCE WITH
REFERENCED SPECIFICATIONS, CODES
AND ALL LIABILITY UNDER CONTRACT.

PER: _____
DATE: _____

NOTES:
1. SEE F113982 AND F113983 FOR ROUTE DATA TABLE AND PULLING CALCULATIONS.

IT IS A VIOLATION OF THE PROFESSIONAL LICENSE LAW
FOR ANY PERSON TO ALTER THIS DRAWING IN ANY WAY,
UNLESS ACTING UNDER THE DIRECTION OF A LICENSED
PROFESSIONAL ENGINEER. THE ALTERING CONSULTANT
SHALL AFFIX THEIR SEAL AND THE NOTATION "ALTERED BY"
FOLLOWED BY THEIR SIGNATURE AND DATE OF ALTERATION.



0 10' 20' 40'
HORIZONTAL SCALE IN FEET
0 5' 10'
VERTICAL SCALE IN FEET

ISSUED
FOR PERMITTING

NO.	DATE	W.O.	DESCRIPTION	DWN BY	CKD BY	REVISED	BY	DATE
0	10/03/2025		ISSUED FOR PERMITTING	JAS	LAF	DAG		
0	07/25/2025		ISSUED FOR CONSTRUCTION	JAS	LAF	DAG		
REV	DATE		DESCRIPTION	DRAWN	REVIEW	APPR		

**BURNS
MEDONNELL**

PROJ. NO. 154527

NO.	DATE	W.O.	DESCRIPTION	DWN BY	CKD BY	REVISED	BY	DATE
0	10/03/2025		ISSUED FOR PERMITTING	JAS	LAF	DAG		
0	07/25/2025		ISSUED FOR CONSTRUCTION	JAS	LAF	DAG		
REV	DATE		DESCRIPTION	DRAWN	REVIEW	APPR		

Long Island Power Authority
TIANA — BUELL
OPS BLDG 1
69kV TRANSMISSION LINE

PLAN AND PROFILE SHEET 40 OF 47
SOUTHAMPTON TO DEERFIELD 138kV OPERATED AT 69kV
UNDERGROUND TRANSMISSION ENGINEERING

PSEG LONG ISLAND
175 East Old Country Road
Hicksville, New York



HORIZ: 1"=20' VERT: 1"=5'

DRAWING NO. F114024

SMART NO. RVF69-FU-01197

REVISION 0

CABINET NO. FOLDER NO.

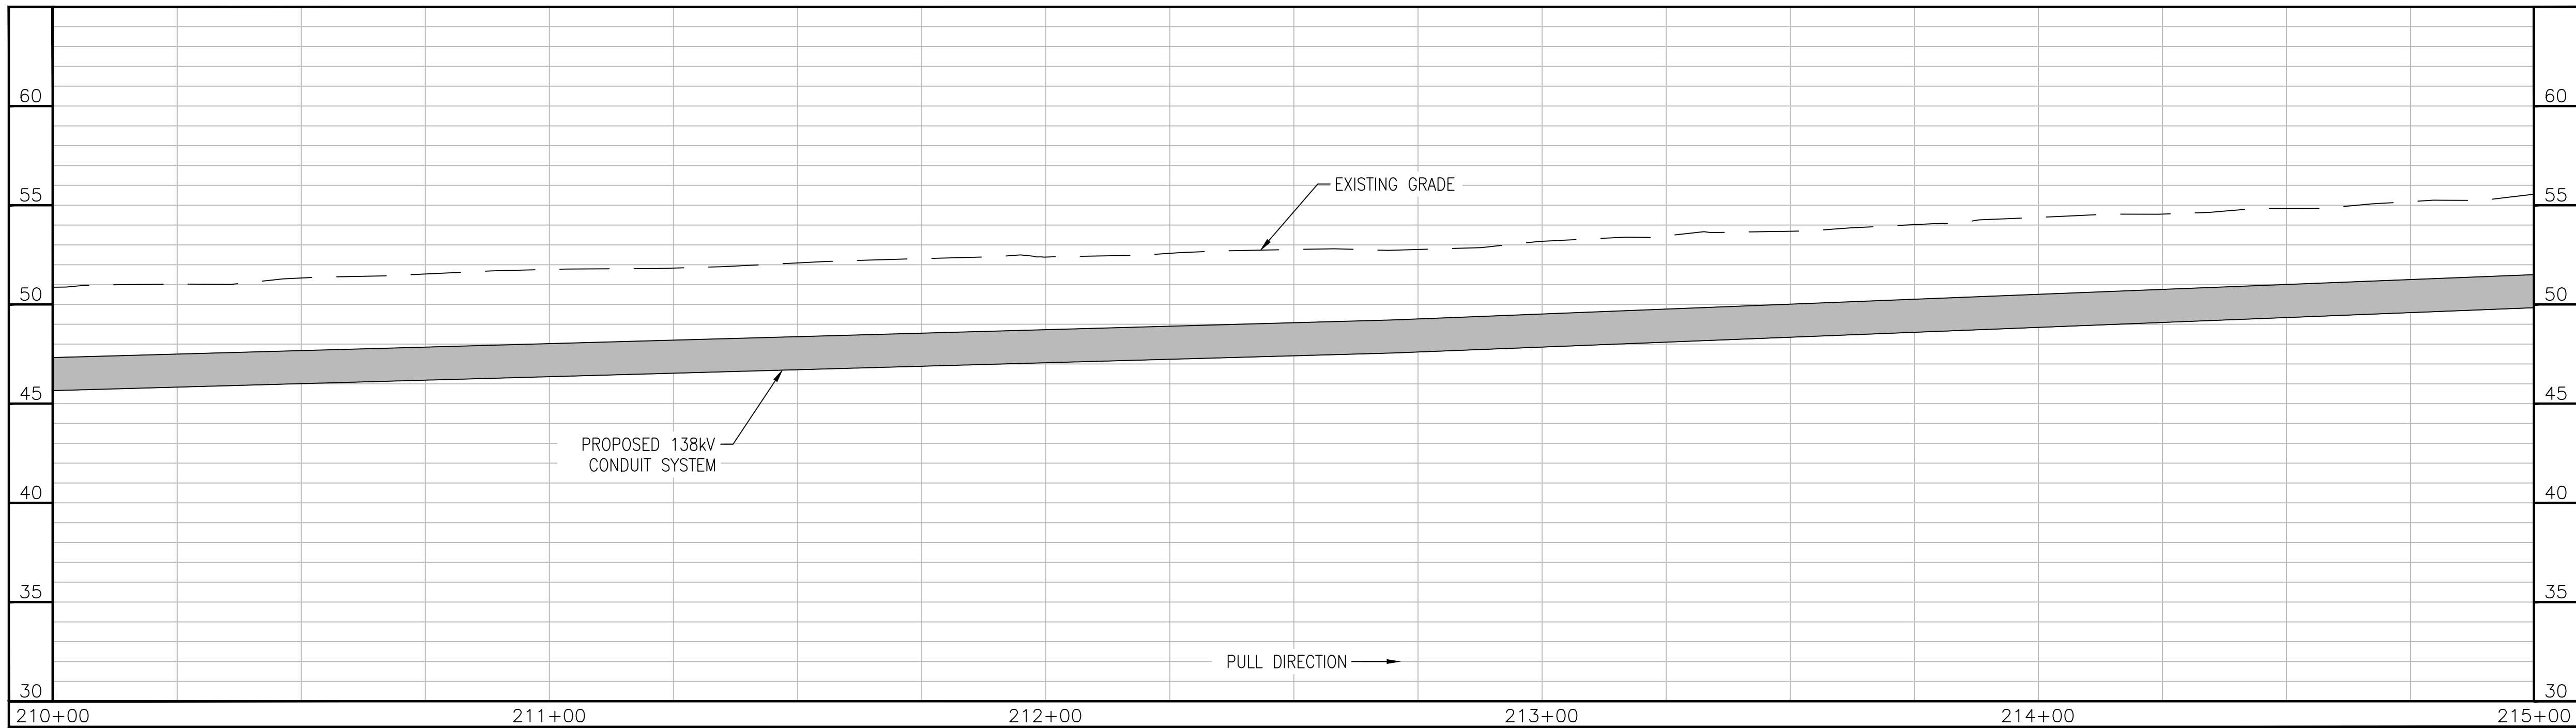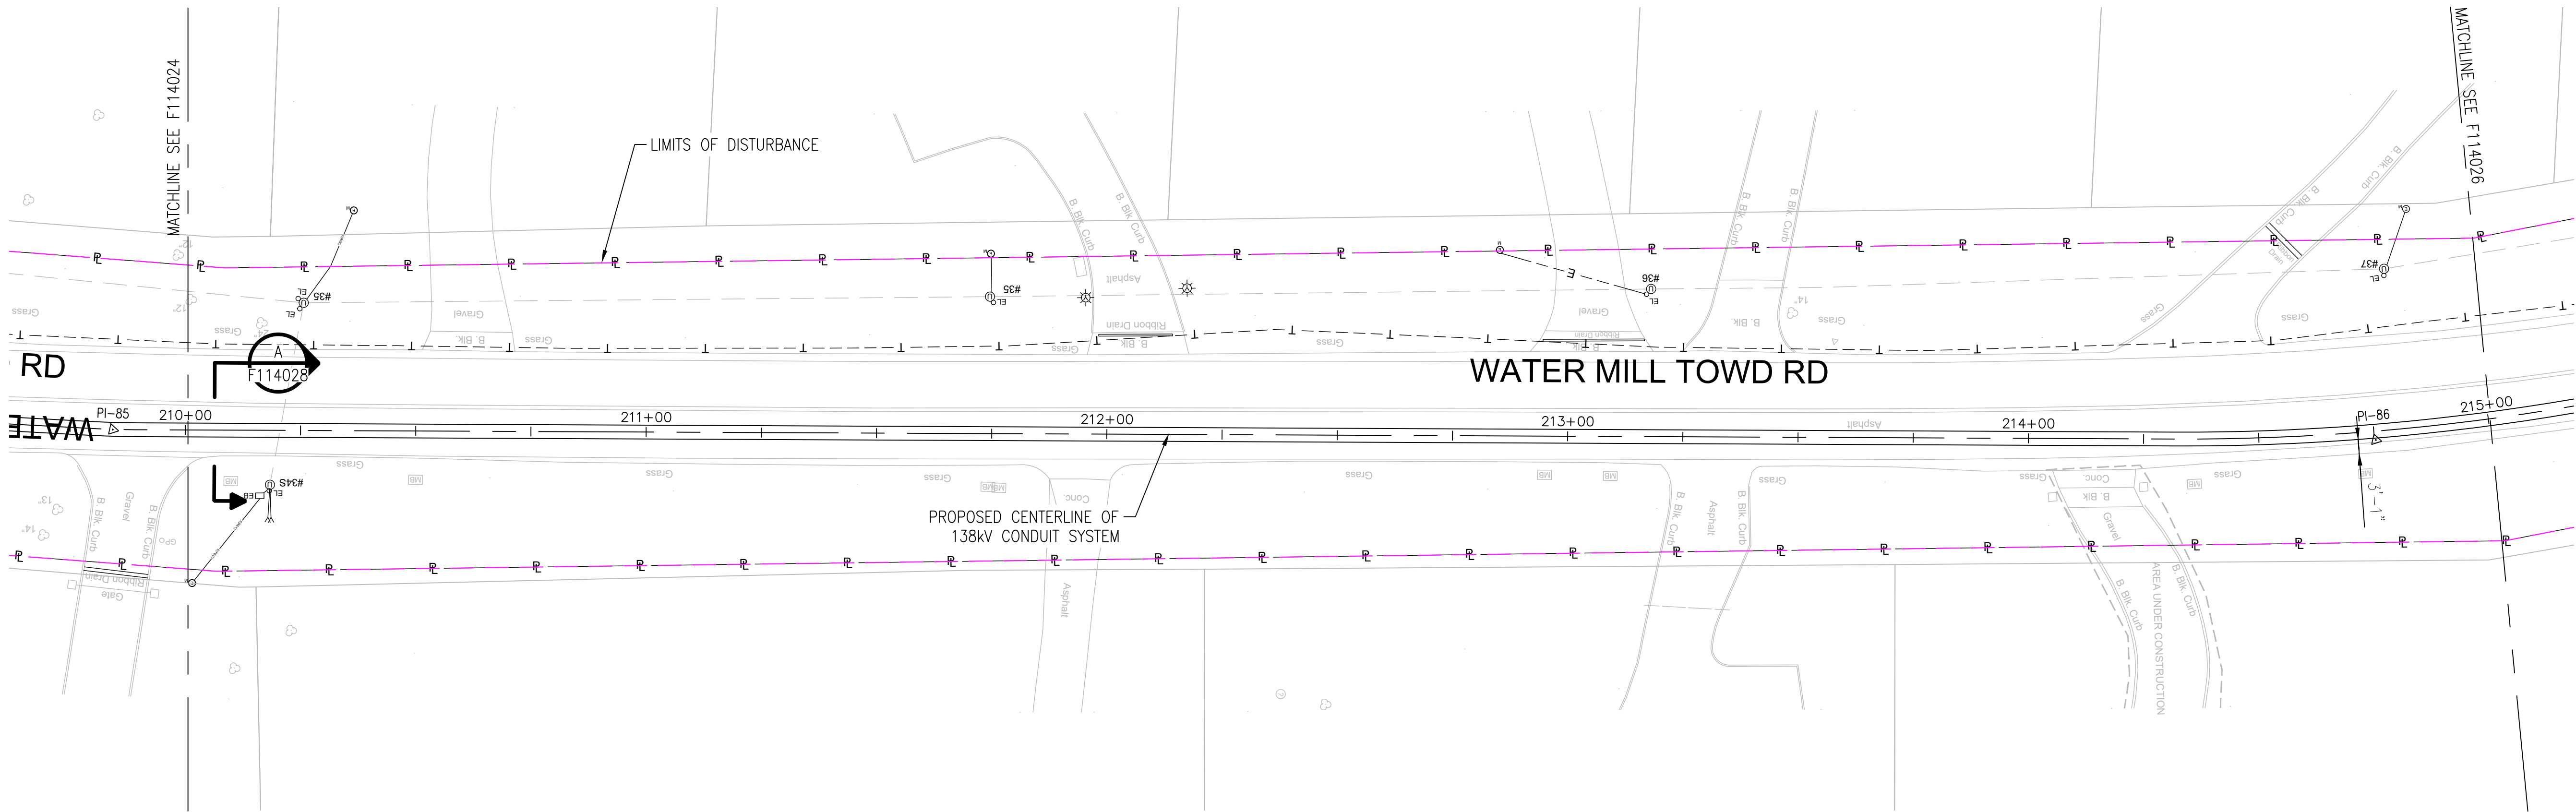

APPROVED WITH
CORRECTIONS AS NOTED
PSEG Long Island


THIS APPROVAL SHALL NOT RELIEVE
THE CONTRACTOR FROM ENTIRE
RESPONSIBILITY FOR DIMENSIONAL
ACCURACY, CONFORMANCE WITH
REFERENCED SPECIFICATIONS, CODES
AND ALL LIABILITY UNDER CONTRACT.

PER: _____
DATE: _____

NOTES:

1. SEE F113982 AND F113983 FOR ROUTE DATA TABLE AND PULLING CALCULATIONS.

IT IS A VIOLATION OF THE PROFESSIONAL LICENSE LAW
FOR ANY PERSON TO ALTER THIS DRAWING IN ANY WAY,
UNLESS ACTING UNDER THE DIRECTION OF A LICENSED
PROFESSIONAL ENGINEER. THE ALTERING CONSULTANT
SHALL AFFIX THEIR SEAL AND THE NOTATION "ALTERED BY"
FOLLOWED BY THEIR SIGNATURE AND DATE OF ALTERATION.

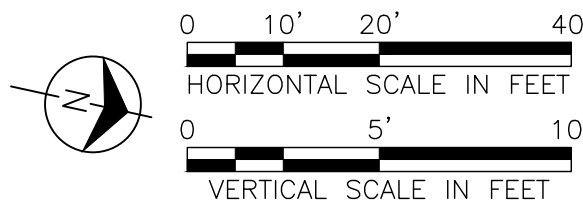

ISSUED
FOR PERMITTING

NO.	DATE	W.O.	DESCRIPTION	DWN BY	CKD BY	REVISED	BY	DATE
0	10/03/2025		ISSUED FOR PERMITTING	JAS	LAF	DAG		
0	07/25/2025		ISSUED FOR CONSTRUCTION	JAS	LAF	DAG		
REV	DATE		DESCRIPTION	DRAWN	REVIEW	APPR		

**BURNS
MEDONNELL**

PROJ. NO. 154527

NO.	DATE	W.O.	DESCRIPTION	DWN BY	CKD BY	REVISED	BY	DATE
0	10/03/2025		ISSUED FOR PERMITTING	JAS	LAF	DAG		
0	07/25/2025		ISSUED FOR CONSTRUCTION	JAS	LAF	DAG		
REV	DATE		DESCRIPTION	DRAWN	REVIEW	APPR		

Long Island Power Authority
TIANA - BUELL
OPS BLDG 1
69kV TRANSMISSION LINE

PLAN AND PROFILE SHEET 41 OF 47
SOUTHAMPTON TO DEERFIELD 138kV OPERATED AT 69kV
UNDERGROUND TRANSMISSION ENGINEERING

PSEG LONG ISLAND
175 East Old Country Road
Hicksville, New York

SCALE
HORIZ: 1"=20' VERT: 1"=5'

DRAWING NO. F114025

SMART NO. RVF69-FU-01197

REVISION 0


CABINET NO. FOLDER NO.



NOTES:

1. SEE F113982 AND F113983 FOR ROUTE DATA TABLE AND PULLING CALCULATIONS.

IT IS A VIOLATION OF THE PROFESSIONAL LICENSE LAW FOR ANY PERSON TO ALTER THIS DRAWING IN ANY WAY, UNLESS ACTING UNDER THE DIRECTION OF A LICENSED PROFESSIONAL ENGINEER. THE ALTERING CONSULTANT SHALL AFFIX THEIR SEAL AND THE NOTATION "ALTERED BY" FOLLOWED BY THEIR SIGNATURE AND DATE OF ALTERATION.

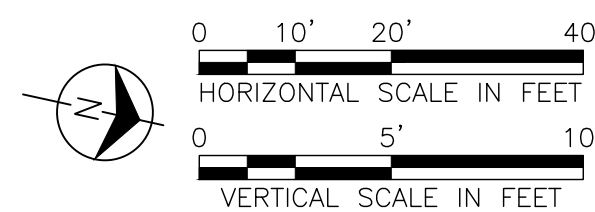

ISSUED
FOR PERMITTING

[illegible]

**BURNS
MCDONNELL**

PROJ. NO. 154527

ISSUE									
	10/03/2024	L39101	ORIGINAL ISSUE						
NO.	DATE	W.O.	DESCRIPTION	DWIN BY	CKD BY	REVIEWED	APPRO		

Long Island Power Authority
TIANA - BUELL
OPS BLDG 1
69kV TRANSMISSION LINE

PLAN AND PROFILE SHEET 41 OF 47
SOUTHAMPTON TO DEERFIELD 138KV OPERATED AT 69KV
UNDERGROUND TRANSMISSION ENGINEERING



SCALE HORIZ: 1"=20' VERT: 1"=5'		VENDOR DWG. NO.	
DRAWING NO. E114025i		SMART NO. RVE69-EU-01197	
		REVISION 0	

	CABINET NO.	FOLDER NO.
--	-------------	------------



APPROVED WITH
CORRECTIONS AS NOTED
PSEG Long Island

THIS APPROVAL SHALL NOT RELIEVE
THE CONTRACTOR FROM ENTIRE
RESPONSIBILITY FOR DIMENSIONAL
ACCURACY, CONFORMANCE WITH
REFERENCED SPECIFICATIONS, CODES
AND ALL LIABILITY UNDER CONTRACT.

PER: _____
DATE: _____

TEMP. _____
DWG. NO. _____

A
B
C
D
E
F

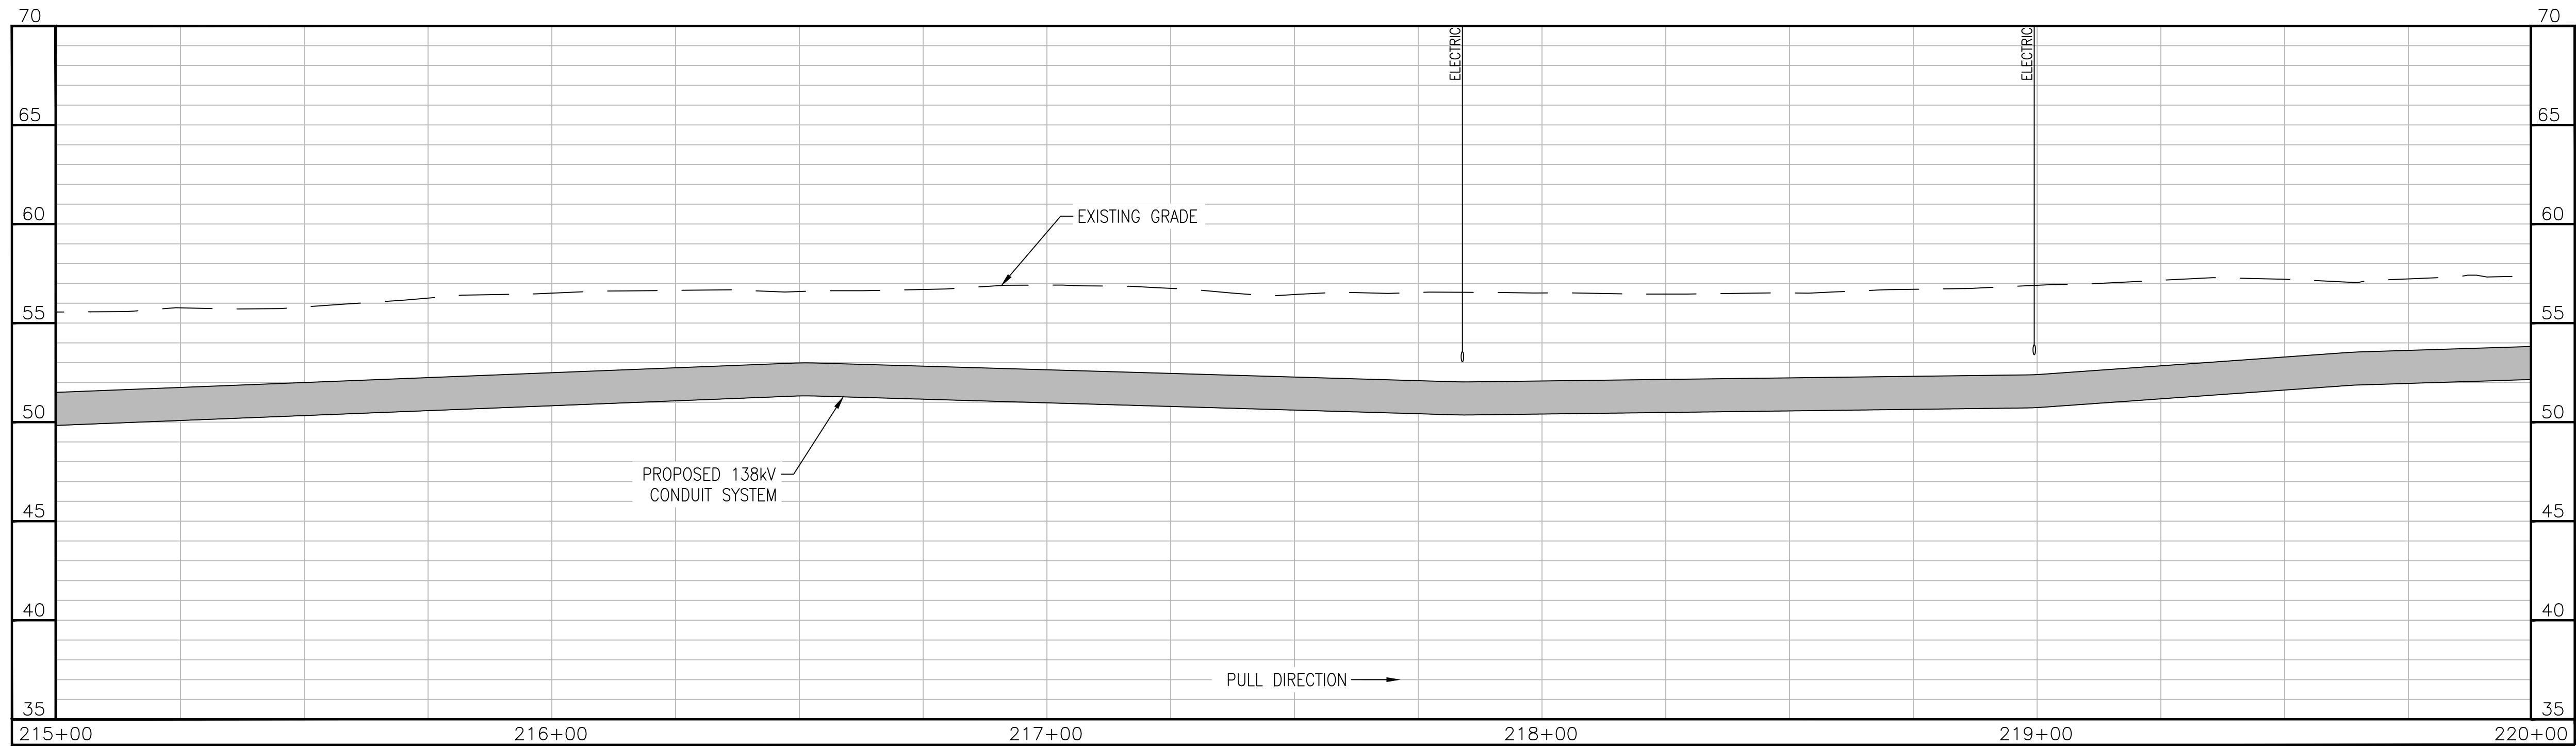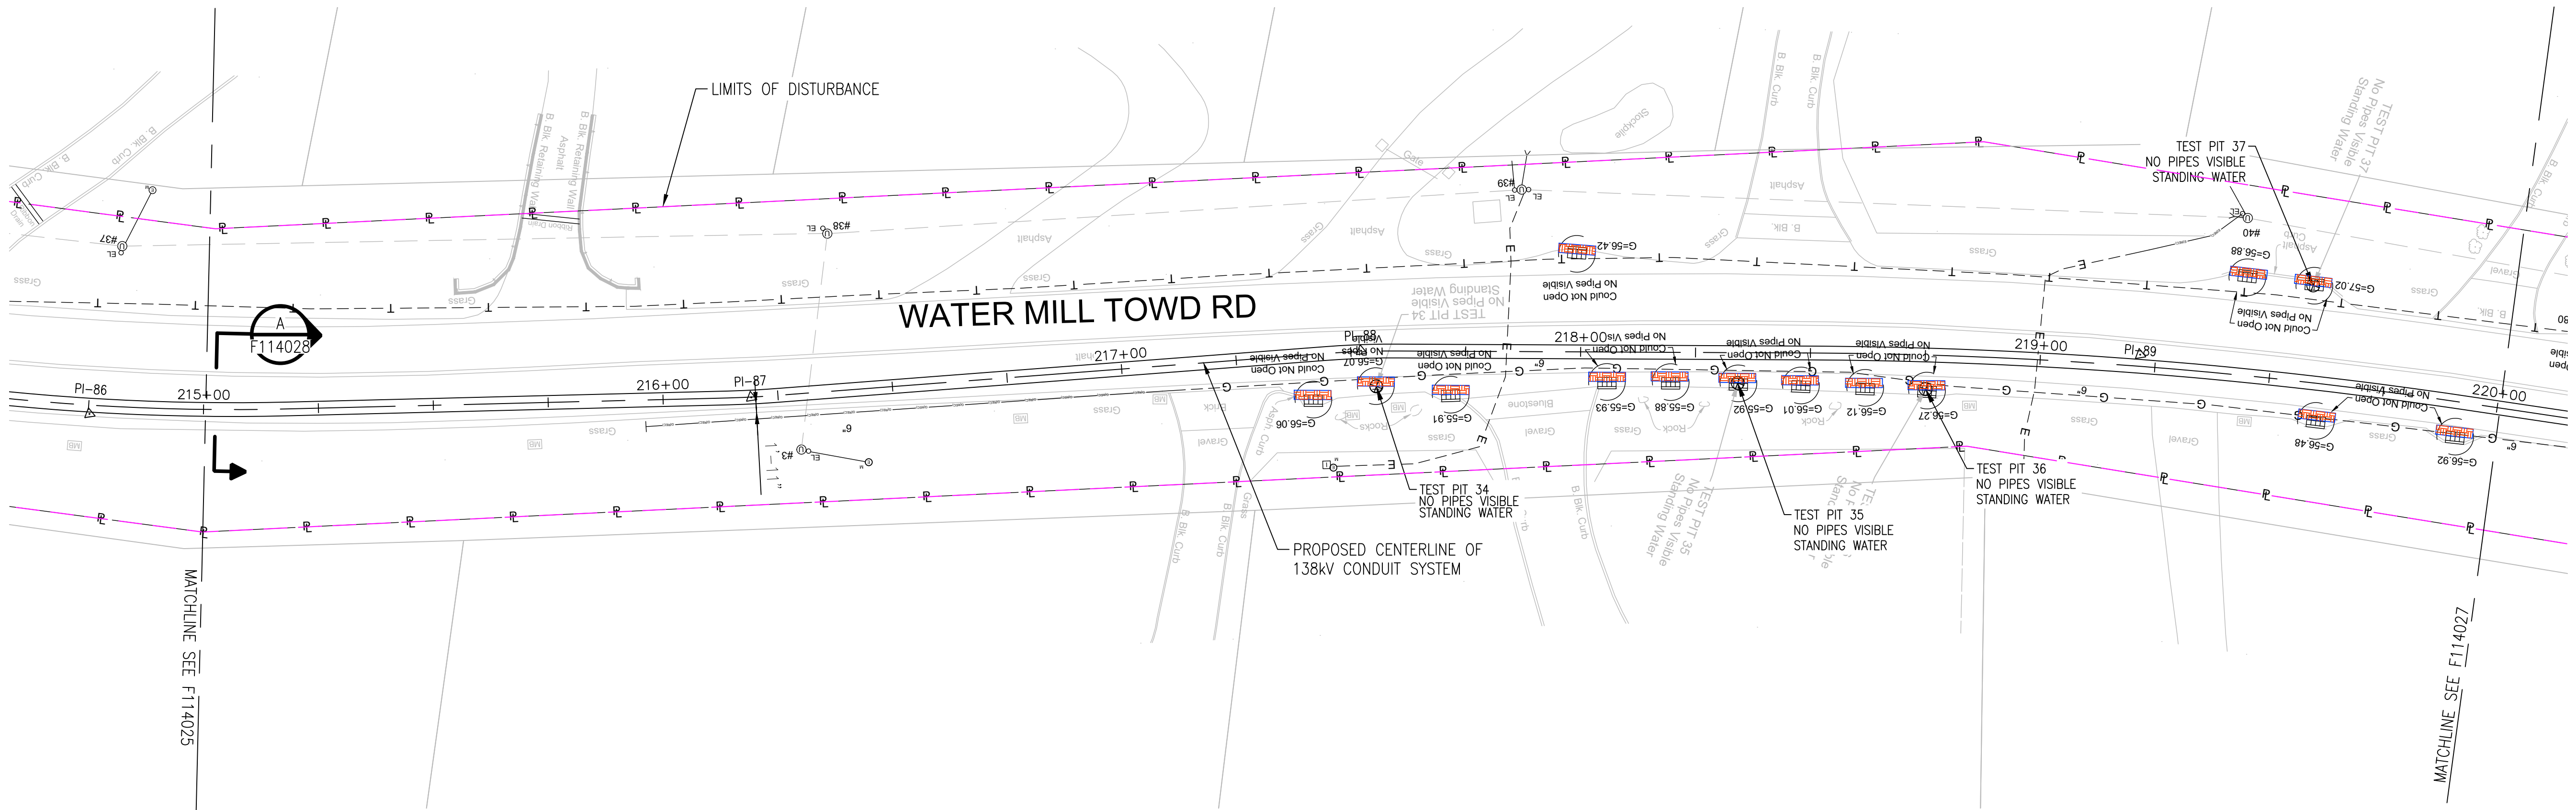


APPROVED WITH
CORRECTIONS AS NOTED
PSEG Long Island

THIS APPROVAL SHALL NOT RELIEVE
THE CONTRACTOR FROM ENTIRE
RESPONSIBILITY FOR DIMENSIONAL
ACCURACY, CONFORMANCE WITH
REFERENCED SPECIFICATIONS, CODES
AND ALL LIABILITY UNDER CONTRACT.

PER: _____
DATE: _____

NOTES:
1. SEE F113982 AND F113983 FOR ROUTE DATA TABLE AND PULLING CALCULATIONS.

IT IS A VIOLATION OF THE PROFESSIONAL LICENSE LAW
FOR ANY PERSON TO ALTER THIS DRAWING IN ANY WAY,
UNLESS ACTING UNDER THE DIRECTION OF A LICENSED
PROFESSIONAL ENGINEER. THE ALTERING CONSULTANT
SHALL AFFIX THEIR SEAL AND THE NOTATION "ALTERED BY"
FOLLOWED BY THEIR SIGNATURE AND DATE OF ALTERATION.

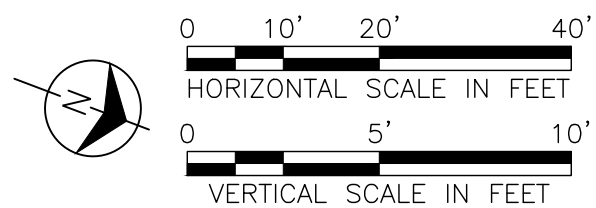

ISSUED
FOR PERMITTING

NO.	DATE	W.O.	DESCRIPTION	DWN BY	CHK BY	REVISED	BY	DATE	APPROVED
0	10/03/2025		ISSUED FOR PERMITTING	JAS	LAF	DAG			
0	07/25/2025		ISSUED FOR CONSTRUCTION	JAS	LAF	DAG			

**BURNS
MCDONNELL**

PROJ. NO. 154527

NO.	DATE	W.O.	DESCRIPTION	DWN BY	CHK BY	REVISED	BY	DATE	APPROVED
0	10/03/2025		ISSUED FOR PERMITTING	JAS	LAF	DAG			
0	07/25/2025		ISSUED FOR CONSTRUCTION	JAS	LAF	DAG			

Long Island Power Authority
TIANA - BUELL
OPS BLDG 1
69kV TRANSMISSION LINE

PLAN AND PROFILE SHEET 42 OF 47
SOUTHAMPTON TO DEERFIELD 138kV OPERATED AT 69kV
UNDERGROUND TRANSMISSION ENGINEERING

PSEG LONG ISLAND
175 East Old Country Road
Hicksville, New York

SCALE
HORIZ: 1"=20' VERT: 1"=5'

DRAWING NO. F114026
SMART NO. RVF69-FU-01198
CABINET NO. FOLDER NO. 0

VENDOR DWG. NO. 0

A


E

C

□

E


F

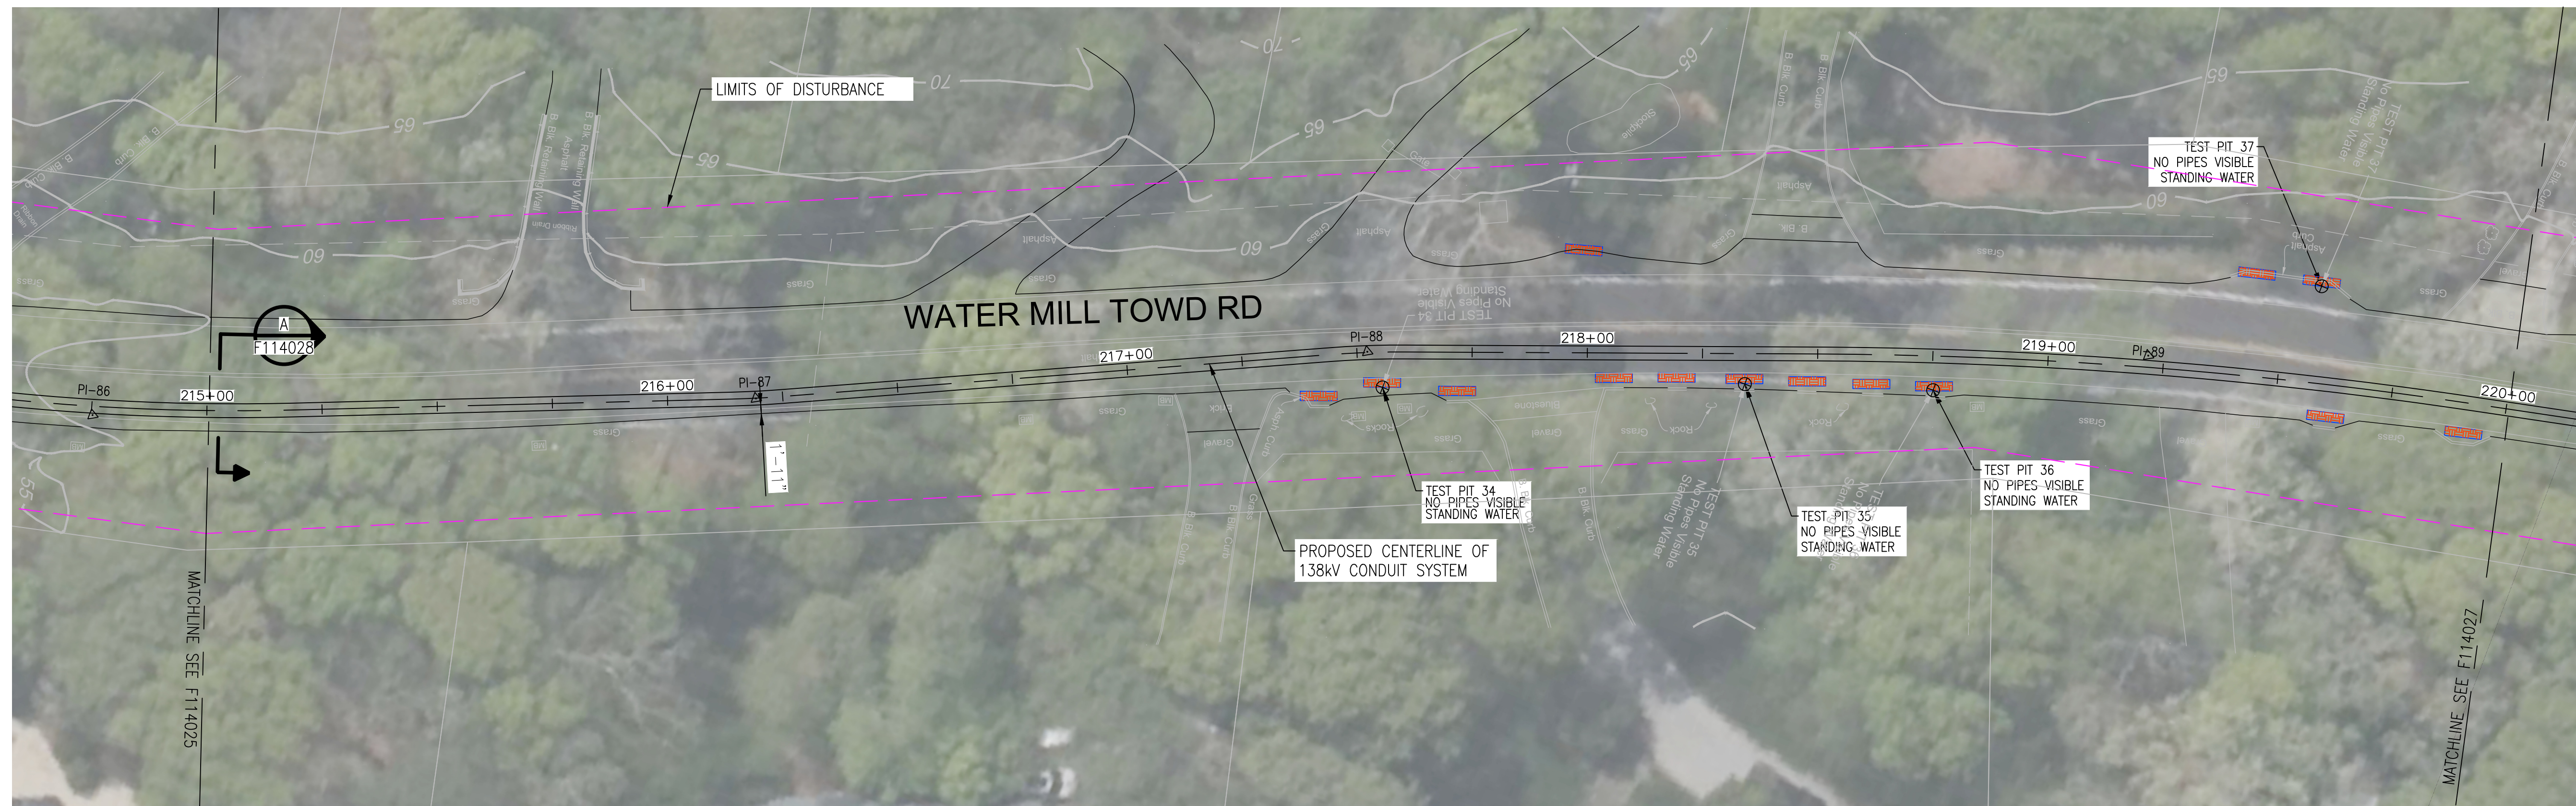

NOTES:

1. SEE F113982 AND F113983 FOR ROUTE DATA TABLE AND PULLING CALCULATIONS.

IT IS A VIOLATION OF THE PROFESSIONAL LICENSE LAW FOR ANY PERSON TO ALTER THIS DRAWING IN ANY WAY, UNLESS ACTING UNDER THE DIRECTION OF A LICENSED PROFESSIONAL ENGINEER. THE ALTERING CONSULTANT SHALL AFFIX THEIR SEAL AND THE NOTATION "ALTERED BY" FOLLOWED BY THEIR SIGNATURE AND DATE OF ALTERATION.

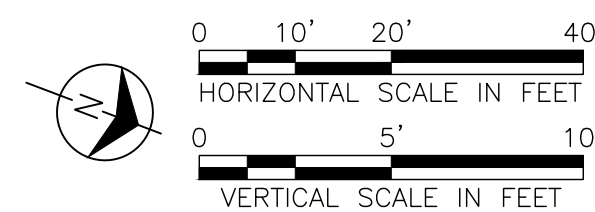

ISSUED
FOR PERMITTING

[illegible]

**BURNS
MCDONNELL**

PROJ. NO. 154527

ISSUE									
	10/03/2024	L39101	ORIGINAL ISSUE						
NO.	DATE	W.O.	DESCRIPTION	DWIN BY	CKD BY	REVIEWED	APPO		

Long Island Power Authority TIANA BUELL OPS BLDG 1 69kV TRANSMISSION LINE			
PLAN AND PROFILE SHEET 42 OF 47 SOUTHAMPTON TO DEERFIELD 138kV OPERATED AT 69kV UNDERGROUND TRANSMISSION ENGINEERING			
 PSEG LONG ISLAND 175 East Old Country Road Hicksville, New York			
SCALE HORIZ: 1"=20' VERT: 1"=5'		VENDOR DWG. NO.	
DRAWING NO. F114026i		SMART NO. RVF69-FU-01198	
SYSTEM GRID NUMBER		CABINET NO.	REVISION 0 FOLDER NO.